

7811 MONTROSE RD

POTOMAC, MD

DRAWING LIST

GENERAL

G0.01

COVER SHEET

STRUCTURAL

S1.011

PART. OF 2ND FL. PLAN AND SECTION

ARCHITECTURAL

A1.10 SITE PLAN
A1.40 FINISH SCHEDULE
A2.01 FIRST & SECOND FLOOR DEMOLITION PLANS
A2.21 FIRST FLOOR PLAN
A2.22 SECOND FLOOR PLAN
A3.01 SOUTH ELEVATION
A3.10 ELEVATION & BUILDING SECTION
A5.01 DEMOLITION SECTION DETAILS
A5.10 PLAN & SECTION DETAILS
A5.11 EXTERIOR PLAN & SECTION DETAILS
A5.21 ENTRY CANOPY DETAILS
A9.00 INTERIOR LOBBY ELEVATIONS
A9.01 MILLWORK

MECHANICAL

MFE-1 GENERAL SPECIFICATIONS
M-1 MECHANICAL SYMBOLS, ABBREVIATIONS AND PARTIAL PLANS

PLUMBING

P-1 PLUMBING SPECIFICATIONS, SYMBOLS, RISERS & ABBREVIATIONS
P-2 FIRST & SECOND FLOOR DEMOLITION & NEW WORK PLANS

ELECTRICAL

E-1 ELECTRICAL SPECIFICATIONS, SYMBOLS AND ABBREVIATIONS
E-2 ELECTRICAL SITE PLAN
E-3 ELECTRICAL FIRST & SECOND FLOOR DEMOLITION PLAN
E-4 ELECTRICAL FIRST & SECOND FLOOR NEW WORK PLAN - LIGHTING
E-5 ELECTRICAL FIRST FLOOR NEW WORK PLAN - POWER & FIRE ALARM
E-6 ELECTRICAL PANEL SCHEDULE AND RISER DIAGRAM

WDG

WDG Architecture, PLLC
1025 Connecticut Avenue NW
Suite 300
Washington DC 20036
tel 202 857 8300
fax 202 463 2198
e-mail wdg@wdgarch.com

Structural

Tadger-Cohen-Edelson
Associates
1109 Spring Street
Suite 510
Silver Spring, MD 20910
tel (301) 587-1820
fax (301) 588-1966
e-mail tadgerco.com

MEP

WFT Engineering, Inc.

9737 Washingtonian Boulevard
Suite 588
Gaithersburg, MD 20878
tel (301) 230-0811
fax (301) 330-8911
e-mail wfteng.com

7811 MONTROSE RD
POTOMAC, MD

WILLCO
Companies

7811 Montrose Road
Suite 500
Potomac, MD 20854

PERMIT SUBMISSION 10/15/13

Professional Seal

I certify that these documents were prepared or approved by me and that I am a duly licensed architect under the laws of the State of Maryland, License Number 9332-A, Expiration Date 10-31-2015.

WDG Project No:
WA11042

COVER SHEET

Scale: As indicated

G0.01

Project Image



Abbreviations

ABBR	TERM	ABBR	TERM	ABBR	TERM	ABBR	TERM
#	AND	DW	DRYWALL	JAN	JANITOR	R.	RADIUS
@	AT	DWG	DRAWING	JC	JANITORS CLOSET	RB	RESILIENT BASE
±	PLUS / MINUS			JOINT		RECT	RECTANGULAR
1SR5	ONE-PART SILICONE RUBBER SEALANT	EA	EACH	L	LENGTH	REF	REFERENCE
2PUM5	TWO-PART POLYURETHANE MODIFIED SEALANT	EC	ELECTRICAL CONTRACTOR	LAM	LAMINATE	REINF	REINFORCING
2PUS	TWO-PART POLYURETHANE SEALANT	EM	ENTRANCE MAT	LAV	LAVATORY	REQD	REQUIRED
		EPJF	EXPANDED POLYETHYLENE JOINT FILLER	LBS	POUNDS	REV	REVISION
A.W.I	ARCHITECTURAL WOODWORKING INSTITUTE	EQ	EQUAL	LN	LINEAR	RF	ROOF
ABV	ABOVE	EQUIP	EQUIPMENT	LT	LIGHT / LIGHTING	RF	RESILIENT FLOORING
ACOUS	ACOUSTICAL	EX	EXISTING	MAR	MARBLE	RL	RELOCATED
ACT	ACOUSTICAL CEILING TILE	EXH	EXHAUST	MAS	MASONRY	RM	ROOM
ADA	ABOVE FINISHED FLOOR	EXP	EXPANSION	MAX	MAXIMUM	RO	ROUGH OPENING
ADJ	ADJUSTIBLE			MDF	MEDIUM DENSITY FIBER BOARD	RT	RESILIENT TILE
AFP	ABOVE FINISHED FLOOR	FI	FURNISH AND INSTALL	MDO	MEDIUM DENSITY OVERLAY	SAN	SANITARY
ALS	ACRYLIC LATEX SEALANT	FAB	FABRICATE	MEDH	MEDIUM DENSITY OVERLAY	SC	SOLID CORE
ALUM	ALUMINUM	FE	FIRE EXTINGUISHER	MECH	MECHANICAL	SF	SQUARE FOOT
ANOD	ANODIZED	FIN	FINISHED	MEMB	MEMBRANE	SHT	SHEET
AP	ACCESS PANEL	FLG	FLOORING	MFD	MANUFACTURED	SIM	SIMILAR
ASSEM	ASSEMBLY	FLR	FLOOR	MFR	MANUFACTURER	SPEC	SPECIFICATION
AVG	AVERAGE	FLUC	FLUORESCENT	MIL	MILLIMETER	SQ	SQUARE
		FO	FACE OF	MIN	MINIMUM	SQ YD	SQUARE YARD
BC	BRICK COURSE	FP	FIREPROOFING	MIRK	MIRROR	SS	STAINLESS STEEL
BITUM	BITUMINOUS	FR	FIRE RATED	MISC	MISCELLANEOUS	SSS	SILICONE SANITARY SEALANT
BKT	BRACKET	MO	MASONRY OPENING	ST	STONE	STD	STANDARD
BLDG	BUILDING	FTG	FOOTING	MTL	METAL	STL	STEEL
BLT-IN	BUILT-IN			MULL	MULLION	STRUC	STRUCTURE / STRUCTURAL
		GA	GALVE	NIC	NOT IN CONTRACT	SUP	SUPPLY
CA	CONSTRUCTION ADMINISTRATOR	GALV	GALVANIZED	NO	NUMBER	SYM	SYMMETRICAL
CAB	CABINET	GC	GENERAL CONTRACTOR	NOM	NOMINAL	SYS	SYSTEM
CC	CEMENTITIOUS COATING	GDS	GARBAGE DISPOSAL	NTS	NOT TO SCALE		
CCT	COVE CERAMIC TILE	GFRG	GLASS FIBER REINFORCED CONCRETE			TBD	TO BE DETERMINED
CEM	CEMENT	GL	GLASS / GLAZING / GLAZE			TBS	TO BE SPECIFIED
CJ	CONTROL JOINT	GR	GRADE			TGL	TEMPERED GLASS
CJP	CORK JOINT FILLER	GUT	GUTTER			THD	THRESHOLD
CL	CENTERLINE	GWB	GYP SUM WALL BOARD			THK	THICK
CLG	CEILING	GYP	GYP SUM			TYF	TYPICAL
CLR	CLR						
CMU	CONCRETE MASONRY UNIT	H	HIGH			UL	UNDERWRITERS LABORATORY
COL	COLUMN	HC	HANDICAPPED			UNO	UNLESS NOTED OTHERWISE
CONC	CONCRETE	HC	HOLLOW CORE			USG	U.S. GYPSUM COMPANY
CONN	CONNECTION	HD	HEAD				
CONST	CONSTRUCTION	HDP	HIGH DENSITY FIBER BOARD			VCT	VINYL COMPOSITION TILE
CONT	CONTINUOUS	HDR	HARDWARE			VERT	VERTICAL
CORR	CORRIDOR	HM	HOLLOW METAL			VEST	VESTIBULE
CPT	CARPET	HNCG	HOLLOW NEOPRENE COMPRESSION GASKET			VIF	VERIFY IN FIELD
CS	CONCEALED SPLINE	HOLD	HOLD DIMENSION				
CT	CERAMIC TILE	HORZ	HORIZONTAL				
		HP	HOLD POINT				
		HT	HEIGHT				
D	DEPTH	HVAC	HEATING, VENTILATING, AND AIR CONDITIONING				
DEMO	DEMOLITION						
DIA	DIAMETER						
DIM	DIMENSION						
DISP	DISPENSER						
DN	DOWN	ID	INSIDE DIAMETER				
DP	DAMP PROOFING	IN	INCH				
DR	DOOR	INSUL	INSULATION				
DTL	DETAIL	INT	INTERIOR				
		J-BX	JUNCTION BOX				
				QTY	QUANTITY		

Project Team

Structural

Tadger Cohen Edelson
Associates, Inc.
1109 Spring St
Suite 510
Silver-Spring, MD 20910
tel (301) 587-1820
fax -
e-mail @tadgerco.com

MEP

WFT Engineering Inc.


9737 Washington Blvd
Suite 588
Gaithersburg, MD 20878
tel (301) 230-0811
fax (301) 330-8911
e-mail @wfteng.com

Landscape


Parker Rodriguez Inc.

101 N. Union St.
Suite 320
Alexandria, VA 22314
tel (703) 548-5010
fax -
e-mail @parkerrodriguez.com

Symbols

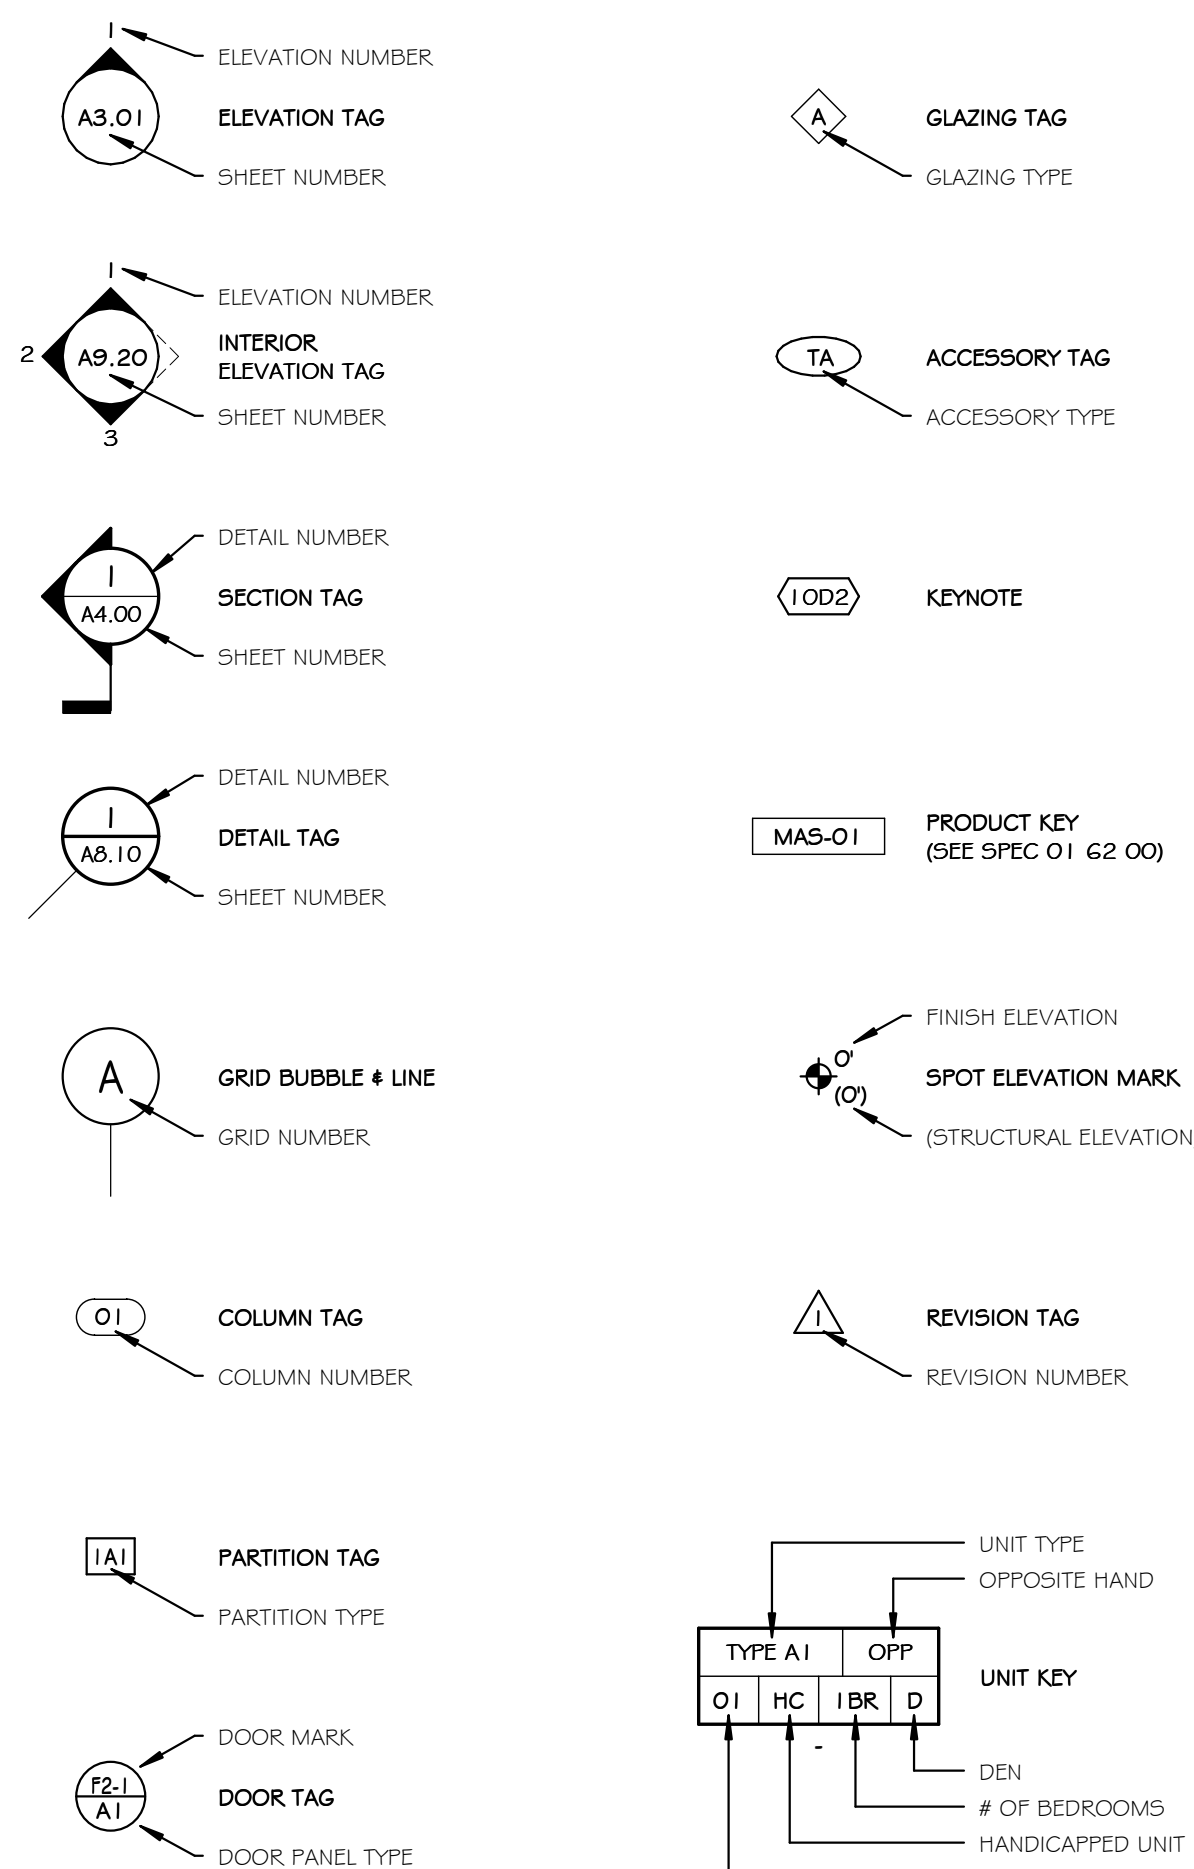

Materials

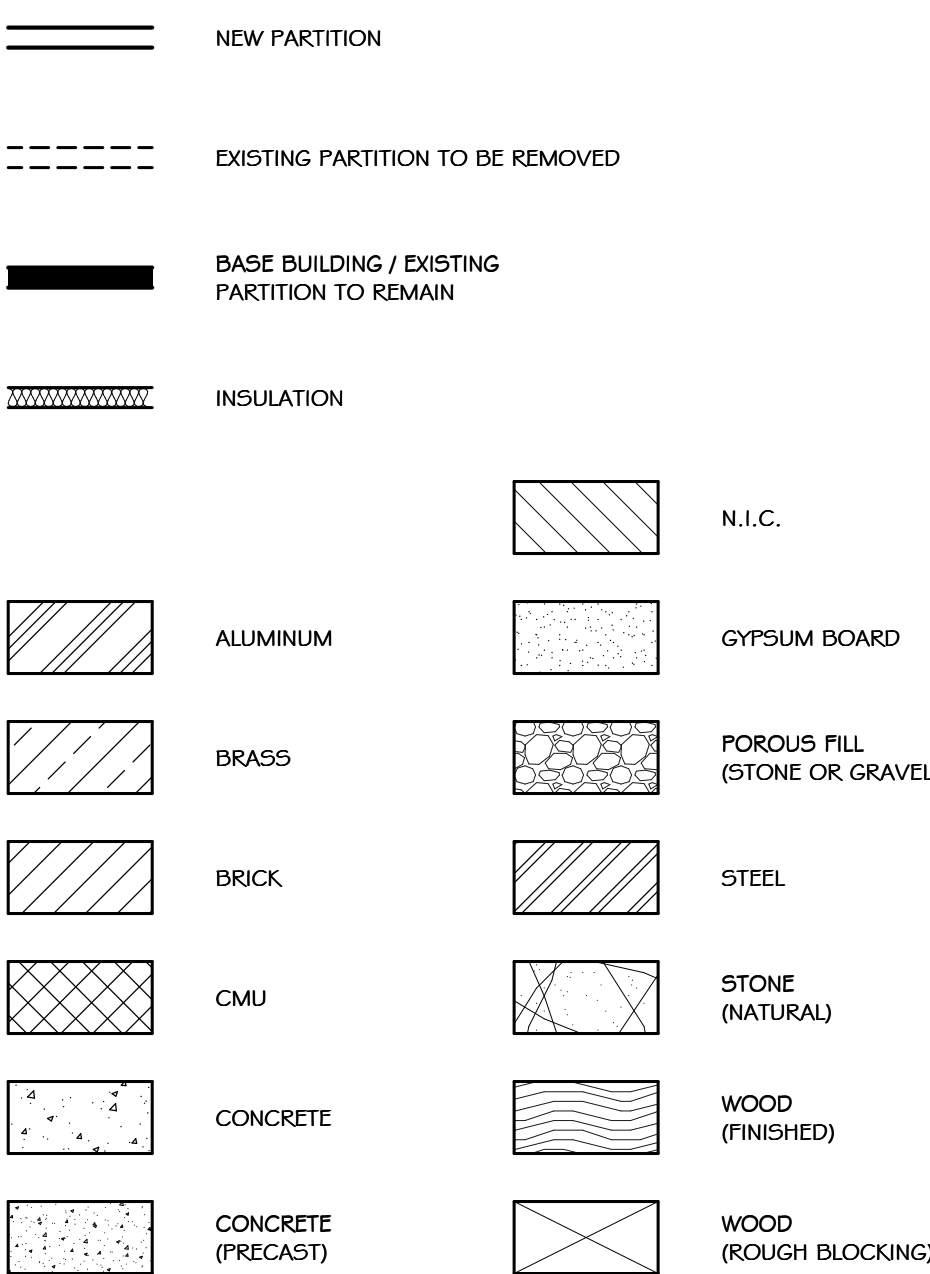

Project Scope

1. REMOVE AND REPLACE EXISTING FLOORING IN MAIN ENTRY LOBBY
2. EXPAND EXISTING ENTRY LOBBY TO INCLUDE NEW SECURITY DESK LOCATION
3. REMOVE AND REPLACE EXISTING CARPET AT 2ND FLOOR ELEVATOR LOBBY
4. REMOVE AND REPLACE EXISTING CEILINGS AT 1ST & 2ND FLOOR ELEVATOR LOBBIES
5. REPLACE EXISTING HANDRAIL SYSTEM AT 2ND FLOOR ELEVATOR LOBBY
6. CLAD EXISTING EXTERIOR CONCRETE COLUMNS WITH WET SEALED THERMOPLASTIC CORE METAL PANEL
7. NEW SECURITY DESK
8. ASSOCIATED MECHANICAL, PLUMBING, & ELECTRICAL WORK AT CEILING & SECURITY DESK

CODE SUMMARY

Description	IBC Required	Provided
-------------	--------------	----------

Chapter 3 - Use and Occupancy Classification

Primary Use Group: Business B

Accessory Use Groups: S-2

Chapter 5 - General Building Heights and Areas

Building Area (GSF): Per Story	9,500 SQFT	UNCHANGED
Section 506 - Allowable Area Per Story due to Automatic Sprinkler System Installation:	37,500 SQFT	UNCHANGED
Building Height:	6'0"	58'
Ave. Grade Plane		UNCHANGED
Type of Construction (Table 503 modified with 403.3.3)	II A	IIA
Number of Stories:	5	5

Chapter 6 - Types of Construction

Type II A Construction per Table 601 w/ Automatic Sprinkler System		
Structural Frame (including columns, girders, trusses)	0 Hours	0 Hours
Bearing Walls - Exterior	0 Hours	0 Hours
Bearing Walls - Interior	0 Hours	0 Hours
Nonbearing Walls and Partitions	0 Hours	0 Hours
Floor Construction (including supporting beams and joists)	0 Hours	0 Hours
Roof Construction (including supporting beams and joists)	0 Hours	0 Hours

Chapter 7 - Fire-Resistance-Rated Construction

Table 704.6 - Maximum Area of Exterior Wall Openings (Greater than 30')

	No Limit	UNCHANGED
--	----------	-----------

Chapter 8 - Interior Finishes Group B

Vertical Exits and Exit Passageways (with Sprinkler)	Class B	UNCHANGED
Exit Access Corridors and Other Exit Ways (with Sprinkler)	Class C	UNCHANGED
Rooms and Enclosed Spaces (with Sprinkler)	Class C	

Chapter 8 - Interior Finishes Group S2

Vertical Exits and Exit Passageways (with Sprinkler)	Class C	UNCHANGED
Exit Access Corridors and Other Exit Ways (with Sprinkler)	Class C	UNCHANGED
Rooms and Enclosed Spaces (with Sprinkler)	Class C	UNCHANGED

Chapter 9 - Fire Protection Systems

The building (all uses) will be sprinklered in accordance with IBC chapter 9

Chapter 10 - Means of Egress Group B

Common Path of Egress	1'00"	UNCHANGED
Maximum Floor Area Allowances Per Occupant	1'00 gross	1'00 gross
Egress width per Occupant Served at Stairways	.2 in	.3 in
Egress width per Occupant Served at Other Egress Components	.15 in	.2 in
Exit Access Travel Distance	300 ft	UNCHANGED
Corridor Fire-Resistance Rating (with Sprinkler System)	0 Hours	0 Hours

Chapter 10 - Means of Egress Group S-2

Common Path of Egress	4'00"	UNCHANGED
Maximum Floor Area Allowances Per Occupant	200 gross	200 gross
Egress width per Occupant Served at Stairways	.2 in	.3 in
Egress width per Occupant Served at Other Egress Components	.15 in	.2 in
Exit Access Travel Distance	250 ft	UNCHANGED
Corridor Fire-Resistance Rating (with Sprinkler System)	0 Hours	0 Hours



MNCPAP APPROVAL STAMP

Montgomery County Planning Board
File No. 81983121A
Certified Site Plan

Chair or Designer
Date

MONTGOMERY COUNTY PLANNING DEPARTMENT
THE MARTYLANDMAN CAPITAL PARK AND PLANNING COMMISSION

DEVELOPER'S CERTIFICATE

The Undersigned agrees to execute all the features of the Site Plan Approval No. 81983121A, including Approval Conditions, Development Program, and Certified Site Plan.

Developer's Name: 7811 Montrose LP/Willco Co. Robert Mazzuca
Company/Contact Person
Address: Willco Companies - 7811 Montrose Road - Polomac, MD 20854
Phone: (240) 399-1421

Signature:

KEY	SYMBOL	MATERIAL	TYPE	FINISH	SIZE	COLOR	MANUFACTURER
PAV-01		CAST-IN-PLACE CONCRETE	N/A	LIGHT BROOM	36" x 36" SCORING	EXISTING	N/A
PAV-02		CONCRETE PAVERS (PEDESTRIAN)	PLANKSTONE®	TUDOR	2 7/8" x 23 1/2" x 4"	T.B.D.	HANOVER ARCHITECTURAL PRODUCTS www.hanoverpavers.com
PAV-03		CONCRETE PAVERS (VEHICULAR)	PLANKSTONE®	NATURAL	2 7/8" x 8 1/4" x 4"	T.B.D.	HANOVER ARCHITECTURAL PRODUCTS www.hanoverpavers.com
PAV-04		STONE BANDS	MESABI BLACK GRANITE	DIAMOND 100	24" x 60" x 2"	COLOR	COLD SPRING GRANITE www.coldspringusa.com
PAV-05		POROUS FLEXIBLE PAVING	NATURAL STONE SURFACE (FS2000)	N/A	N/A	N/A	CAPITOL FLEX-PAVE www.capitolflexpave.com
PAV-06		DECORATIVE GLASS MULCH	T.B.D.	N/A	LARGE	T.B.D.	AMERICAN SPECIALTY GLASS www.american specialtyglass.com

PAVING SCHEDULE

LEGEND

HARDSCAPE


- SITE WALL (W/ STONE VENER) - SEE SHEET L2.12, DETAIL 03
- STEPS (W/ S.S. HANDRAILS) - SEE SHEET L2.12, DETAILS 01/02
- TRENCH DRAIN - SEE SHEET L2.11, DETAIL 02
- PRECAST CONCRETE CURB - SEE SHEET L2.11, DETAIL 01
- AREAS TO BE PLANTED - SEE PLANTING PLAN


FEATURES AND FURNITURE

- SPECIAL FEATURE (W/INTEGRAL LIGHTING) - SEE SHEET L2.50, DETAIL 04
- BENCH - SEE SHEET L2.50, DETAIL 01
- PICNIC TABLE - SEE SHEET L2.50, DETAIL 02
- TRASH RECEPTACLE - SEE SHEET L2.50, DETAIL 03

LIGHTING


- PEDESTRIAN POLE LIGHT - SEE SHEET L4.10, DETAIL 01
- WALL MOUNTED LIGHT - SEE SHEET L4.10, DETAIL 02
- TREE UPLIGHT - SEE SHEET L4.10, DETAIL 03
- TRANSFORMER AND PROPOSED WIRING - SEE ELECTRICAL DWGS.
- DUPLEX OUTLET - WEATHERPROOF - SEE ELECTRICAL DWGS.

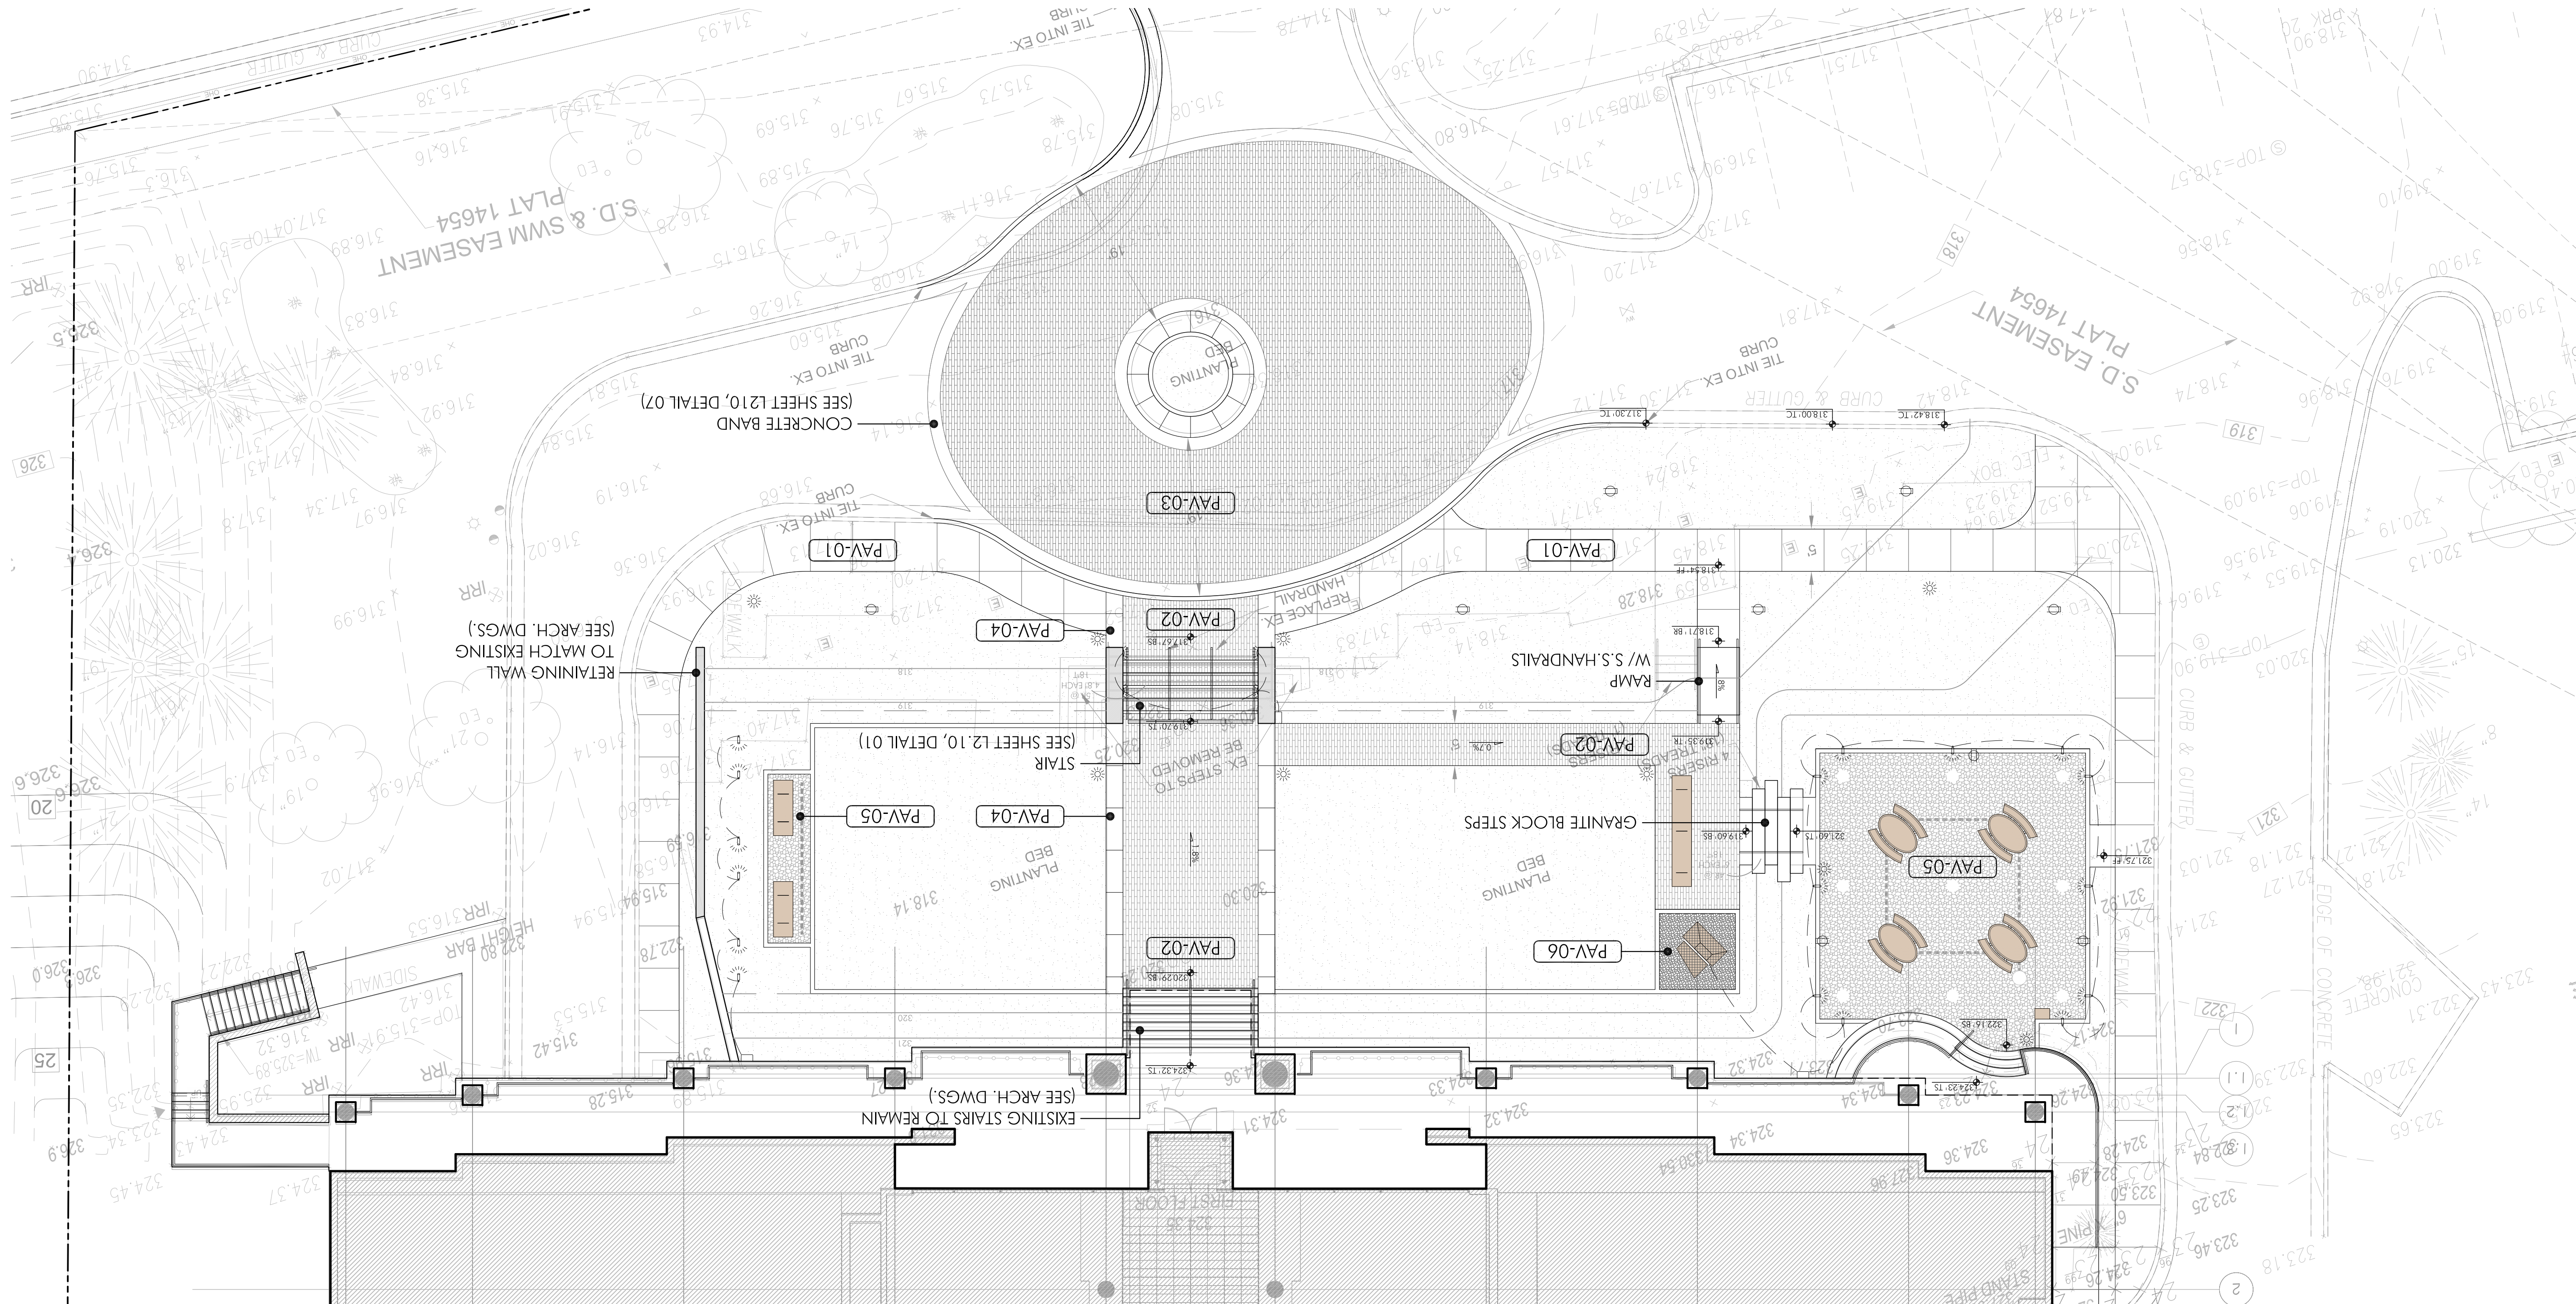

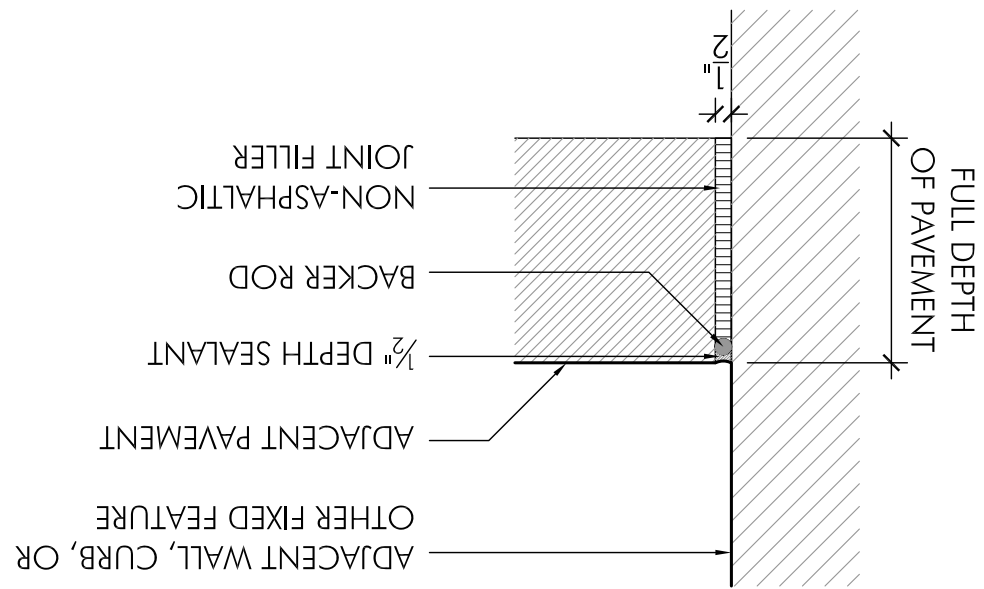


SCALE: N.T.S.

ISOLATION JOINT

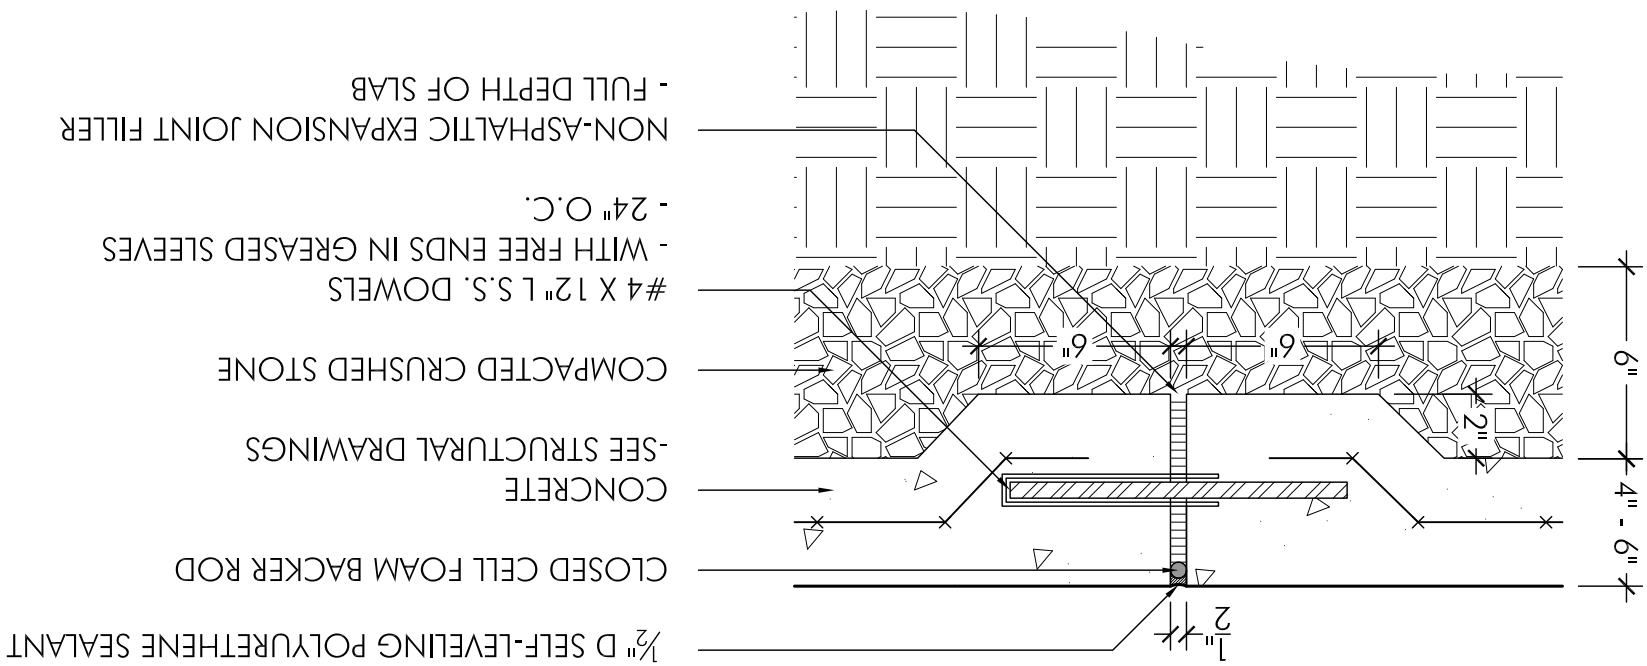


SCALE: N.T.S.

EXPANSION JOINT

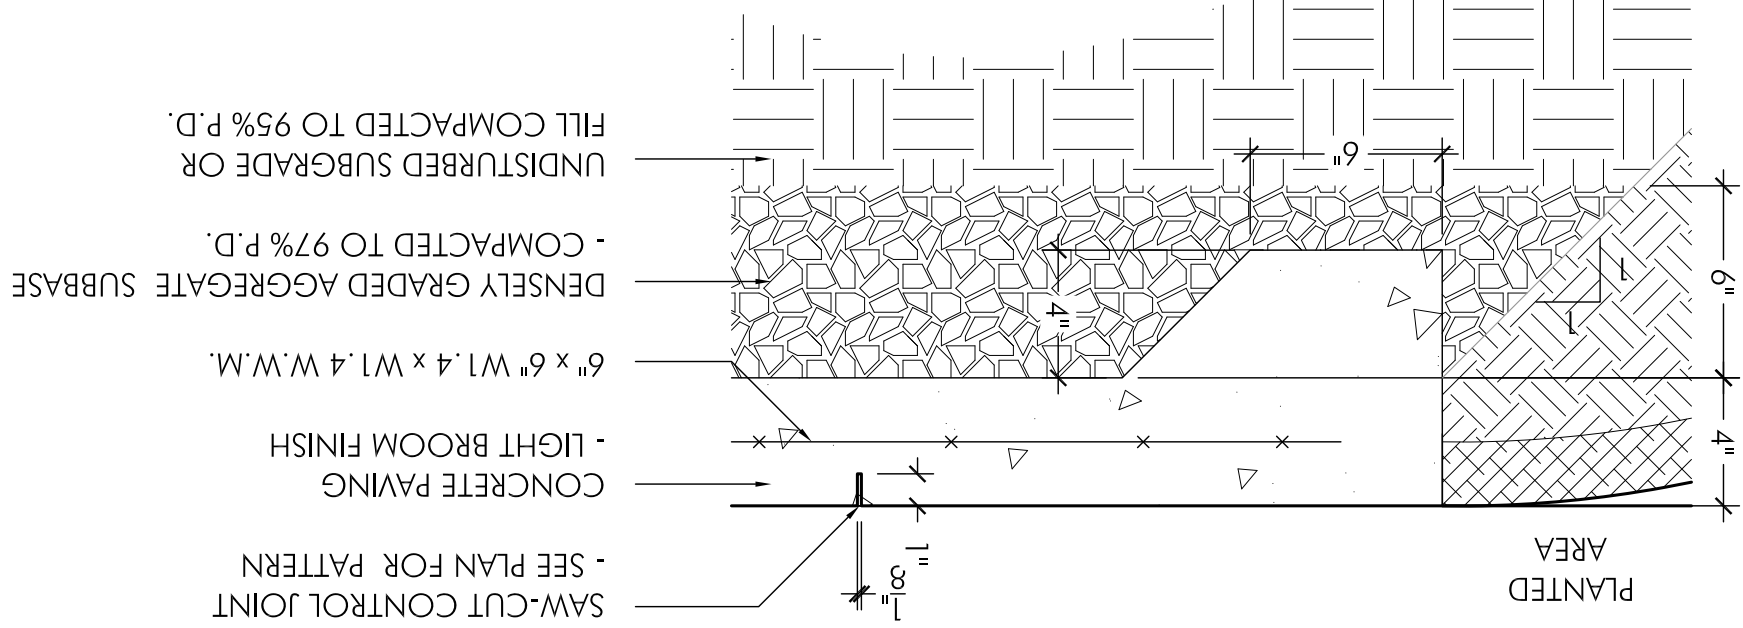


SCALE: N.T.S.

CONCRETE PAVING - CONTROL JOINT (PEDESTRIAN)

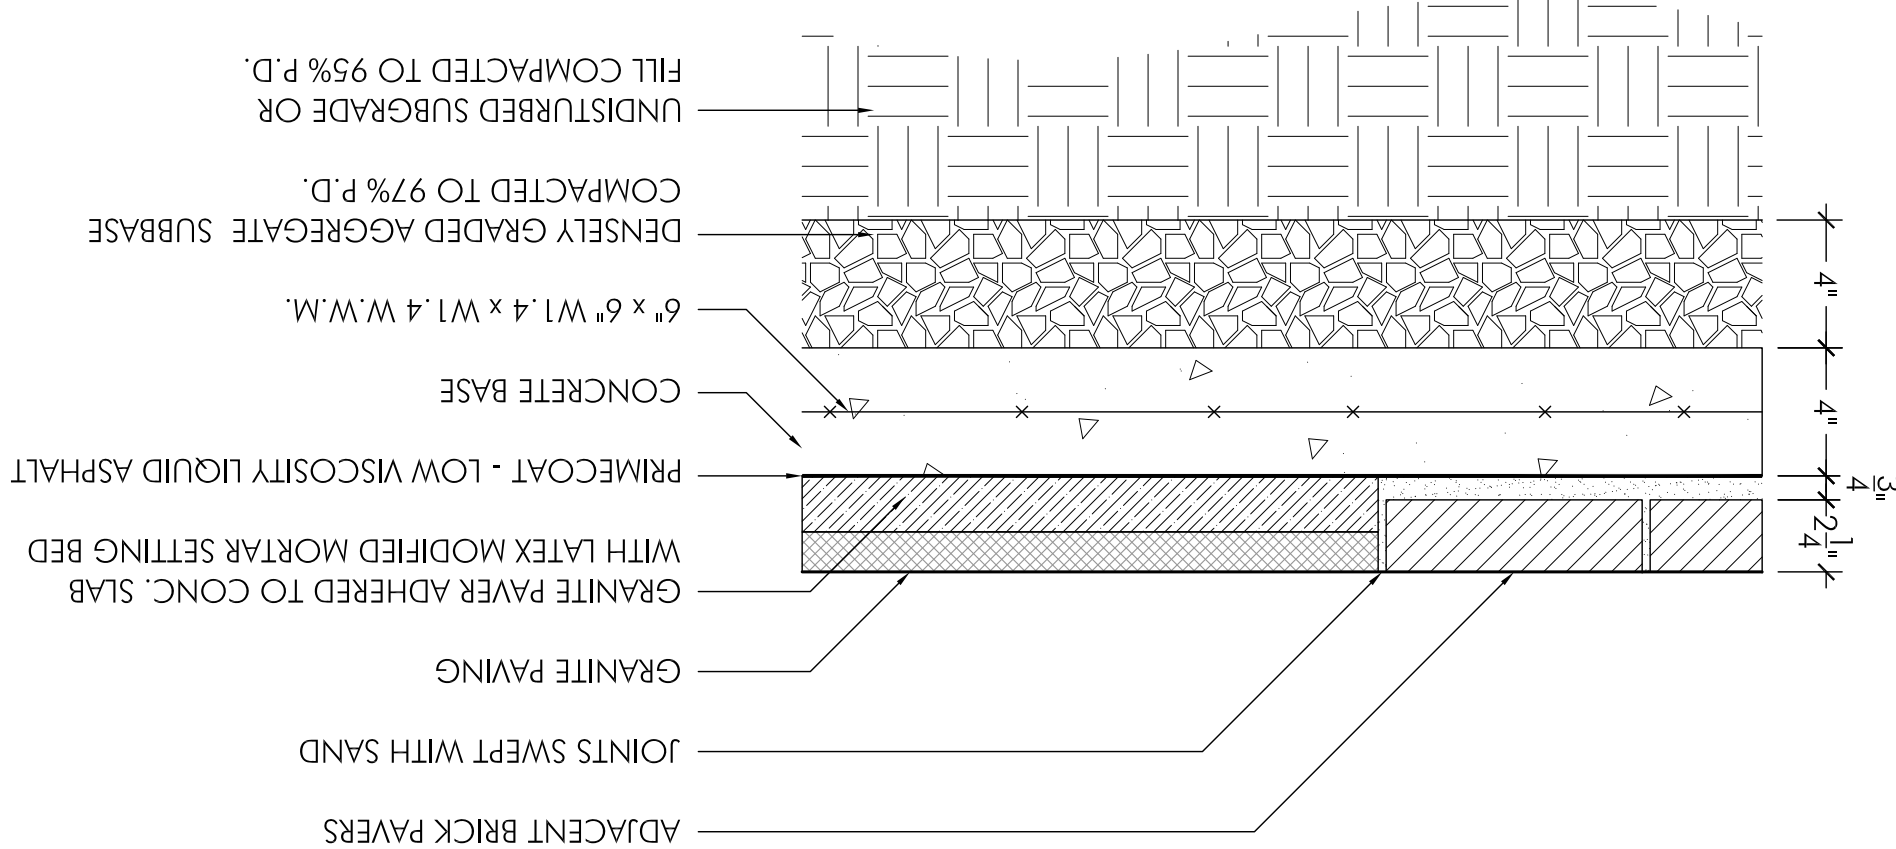


SCALE: N.T.S.

UNIT PAVER / STONE BAND PAVING

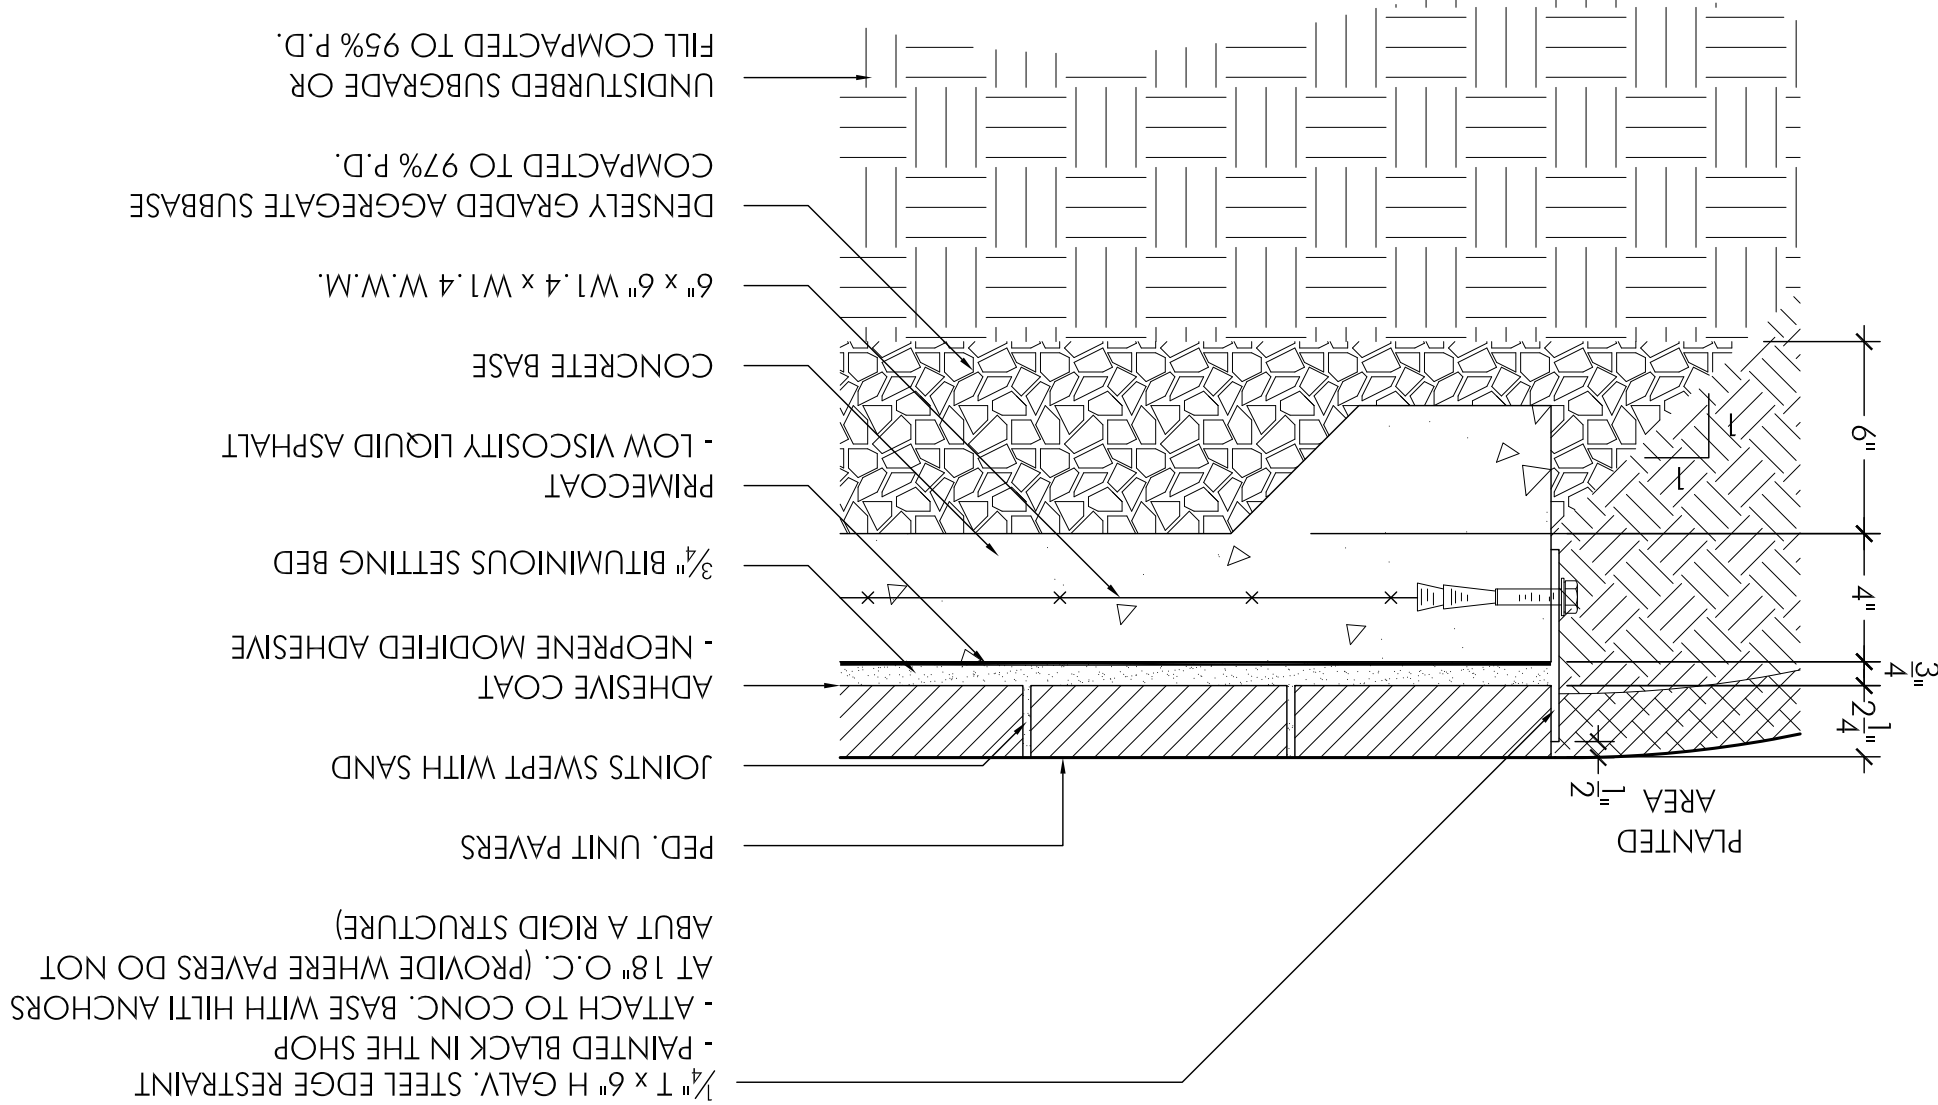


SCALE: N.T.S.

UNIT PAVER (PESTRIAN)

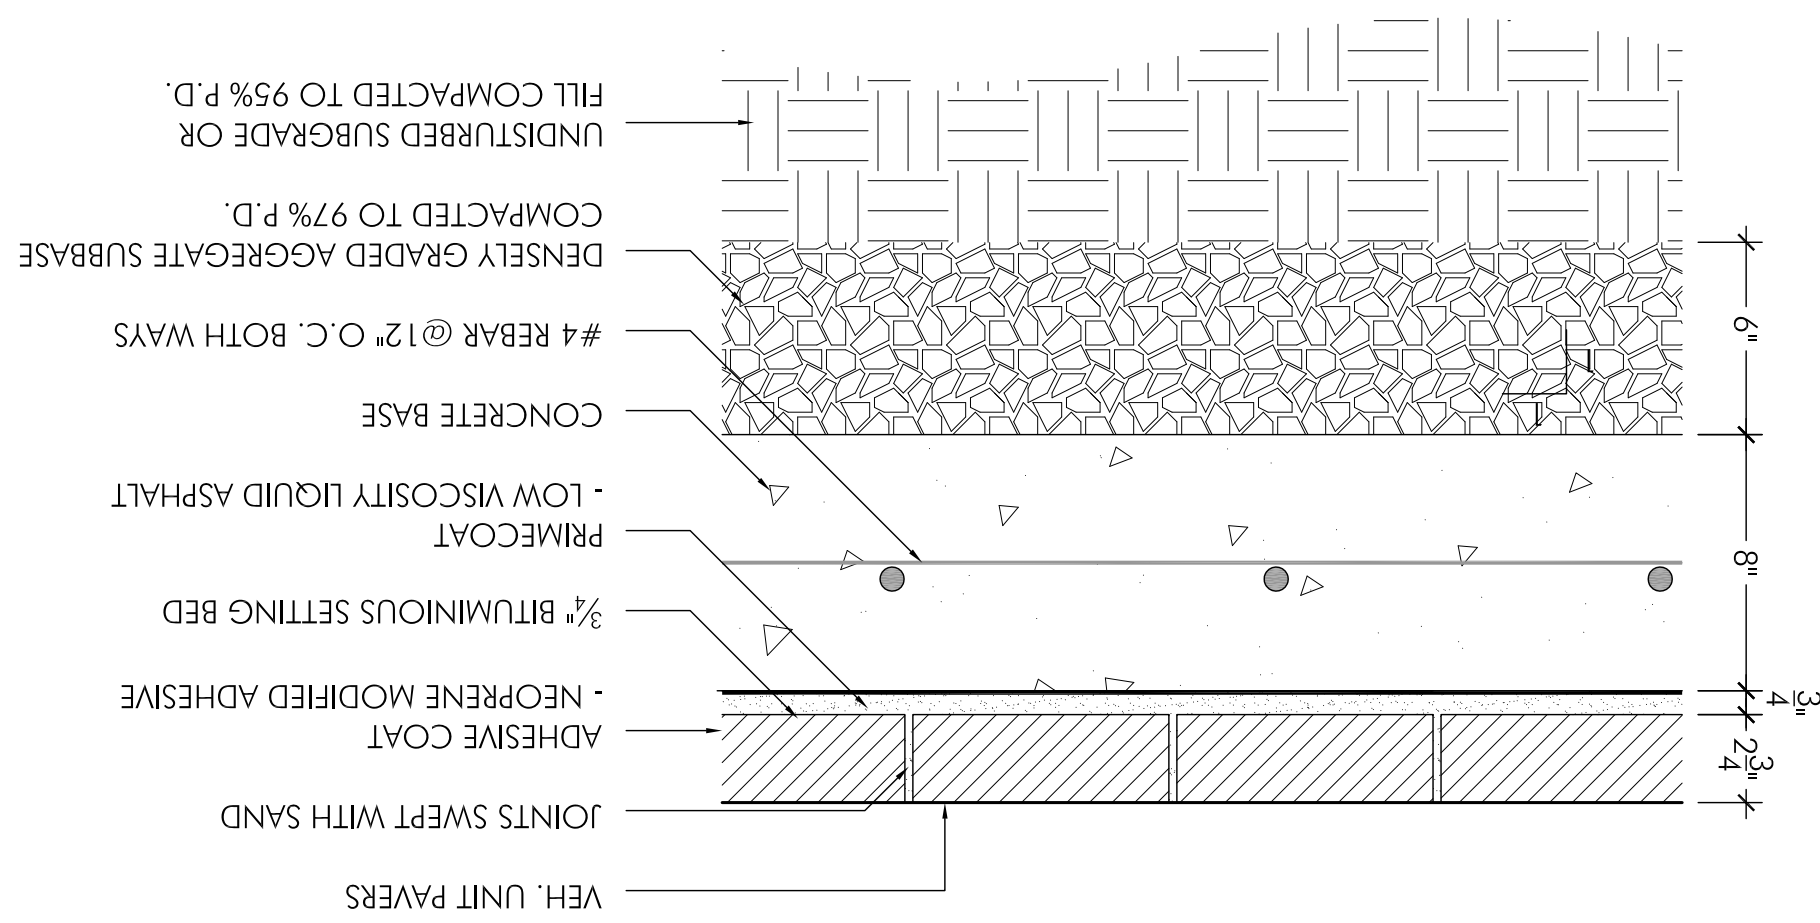

SCALE: N.T.S.

UNIT PAVER (VEHICULAR)

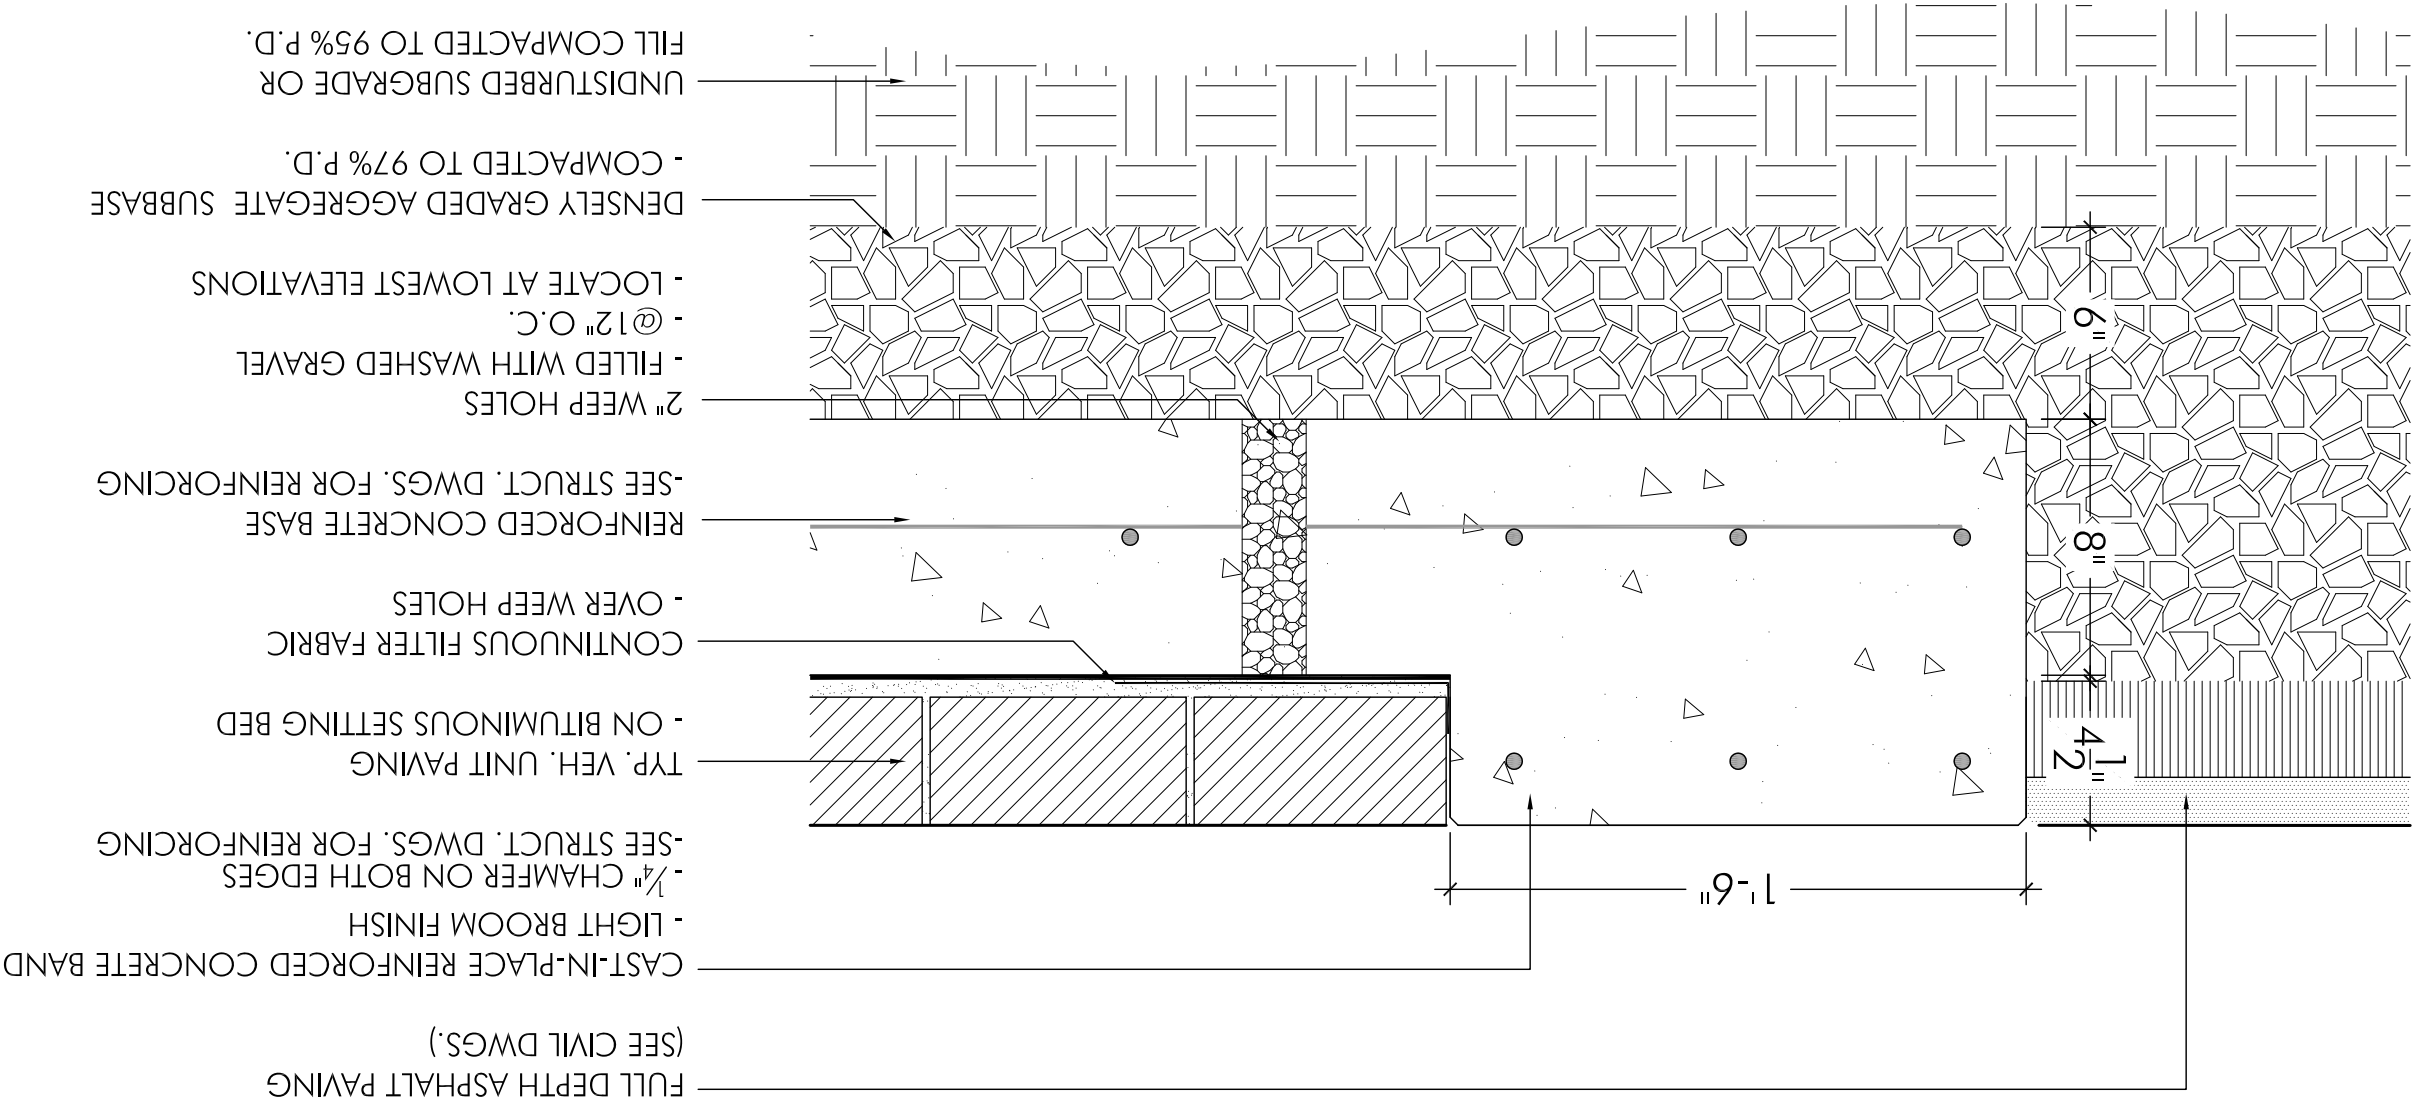

SCALE: N.T.S.

CONCRETE BAND (VEHICULAR)

DEVELOPER'S CERTIFICATE

The undersigned agrees to execute all the features of the Site Plan Approval No. 81983121A, including Approval Conditions, Development Program, and Certified Site Plan.

No. 81983121A

Company/Contact Person

Address: WILCO Companies - 7811 Montrose Road - Potomac, MD 20854

Phone: (202) 399-1421

Signature:

MANPCP APPROVAL STAMP

Chair or Designer

Date

Montgomery County Planning Department


File No. 81983121A

Certified Site Plan

Montgomery County Planning Board

SCALE: N.T.S.

POROUS FLEXIBLE PAVING (PEDESTRIAN)

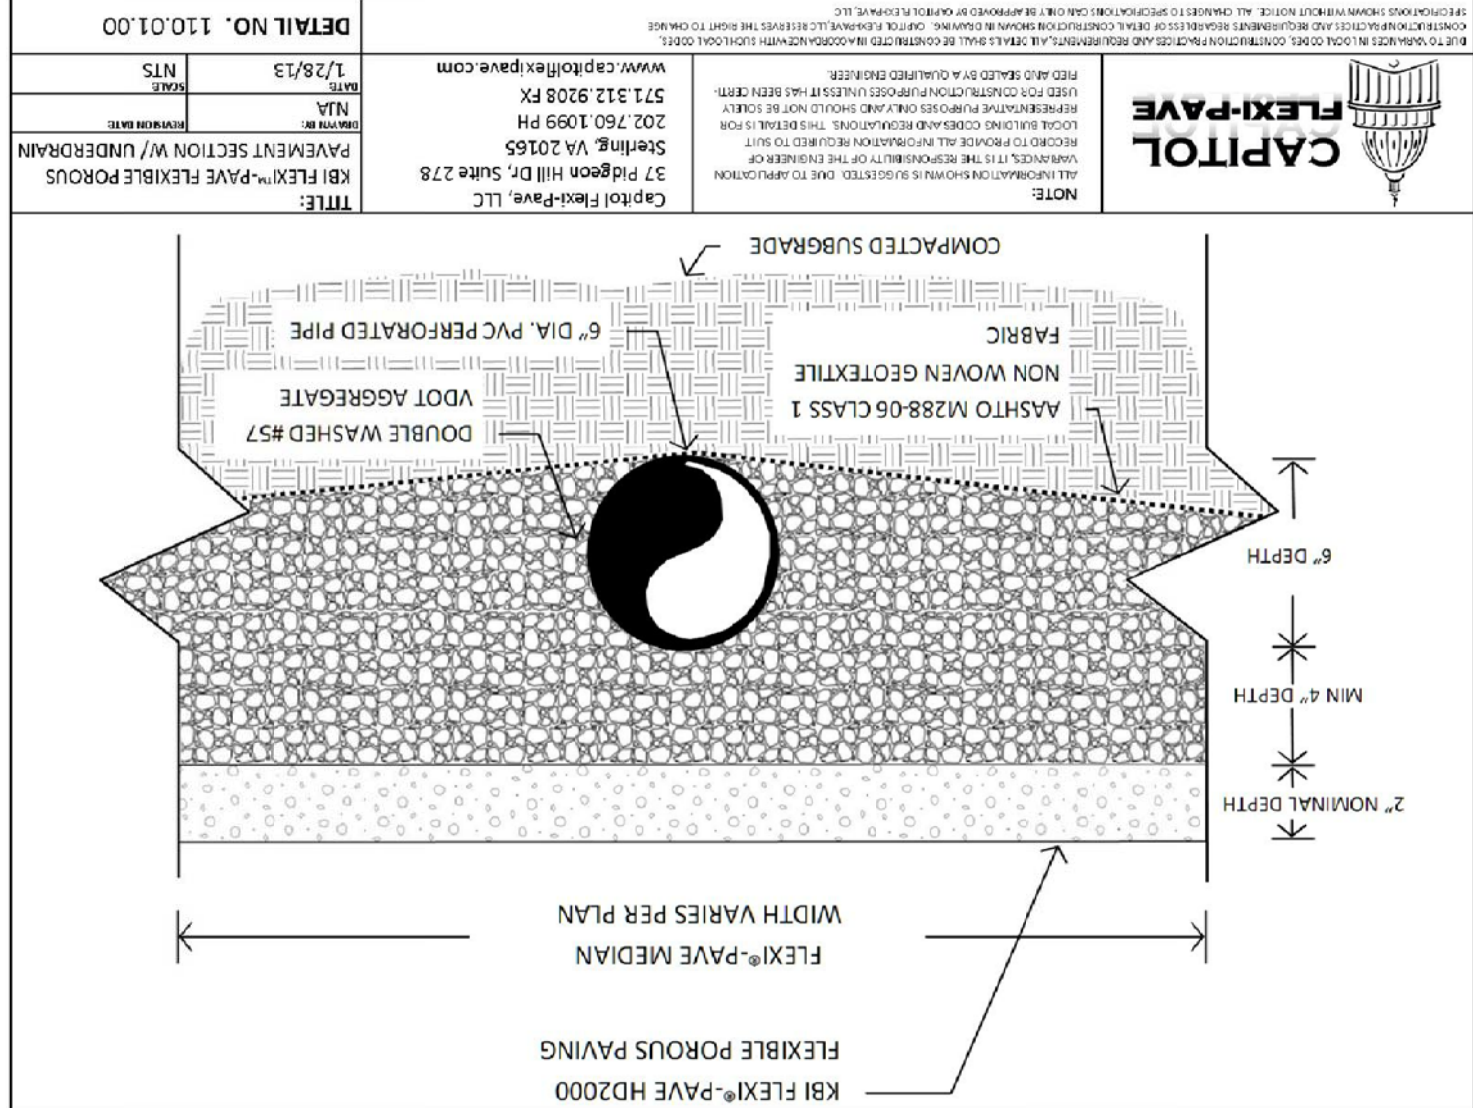

Manufacturer: CAPITOL FLEXI-PAVE

Product: Natural Stone Surface (FS2000)

7811 MONTROSE ROAD

PARKER RODRIGUEZ, INC.

OWNER

WILCO Companies

7811 Montrose Road

Potomac, MD 20854

Architect

WDC Architecture

1025 Connecticut Avenue NW

Washington, DC 20036

202.857.8300

Civil Engineer

Johnson, Berndt, Associates, Inc.

205 North Frederick Avenue

Suite 100


Gaithersburg, MD 20877

301.963.1133



REVISIONS
09/16/13
10/15/13
DESIGN DEVELOPMENT SET
11/14/13
BID SET

HARDSCAPE DETAILS

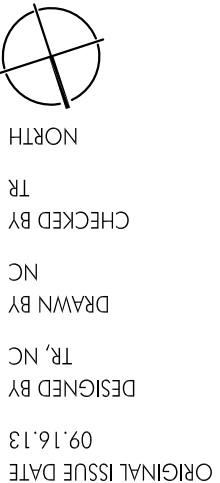

12.10



REVISIONS

SITE PERMIT 09.16.13
DESIGN DEVELOPMENT SET 10.15.13
BID SET 11.14.13

HARDSCAPE
DETAILS

ORIGINAL ISSUE DATE

DESIGNED BY

TR, NC

DRAWN BY

TR, NC

CHECKED BY

SCALE

1"=10'-0"
0' 5' 10'

12.11

12.11

BID SET - 10.15.13 - NOT FOR CONSTRUCTION


MNCPPC APPROVAL STAMP	
Certified Site Plan File No. 81983121A Montgomery County Planning Board	Chair or Designee Date
MONTGOMERY COUNTY PLANNING DEPARTMENT THE MARYLAND NATIONAL CAPITAL PARK AND PLANNING COMMISSION	

DEVELOPER'S CERTIFICATE	
The Undersigned agrees to execute all the features of the Site Plan Approval No. 81983121A, including Approval Conditions, Development Program, and Certified Site Plan.	
Developer's Name: 7811 Montrose LP/WILLCO Co. Robert Mazzuca	Contact Person
Company	Address: WILLCO Companies - 7811 Montrose Road - Potomac, MD 20854
Phone: (240) 399-1421	Signature:

01
PRECAST LANDSCAPE CURB

SCALE : 1" = 1'-0"


- PRECAST CURB NOTES:
1. LENGTH OF PRECAST PIECES TO BE 3 FT., MAX.
 2. COLOR T.B.D.
 3. PROVIDE 2 DOWELS PER CURB UNIT, MIN.
 4. ALL JOINTS TO BE FULLY CAULKED
- COLOR TO MATCH PRECAST.
 5. CORNER UNITS TO BE BUTTED WITH FINISHED ENDS
- DO NOT MITRE.
 6. CONTRACTOR TO PROVIDE SHOP DRAWINGS OF ALL
PRECAST PIECES INDICATING LAYOUT, CORNER DETAILS,
ETC. FOR REVIEW AND APPROVAL BY PROJECT LANDSCAPE
ARCHITECT PRIOR TO FABRICATION.
 7. CONTRACTOR TO PROVIDE REPRESENTATIVE PRECAST
AND JOINT SEALANT COLOR/FINISH SAMPLES FOR REVIEW
AND APPROVAL BY PROJECT LANDSCAPE ARCHITECT PRIOR
TO FABRICATION.

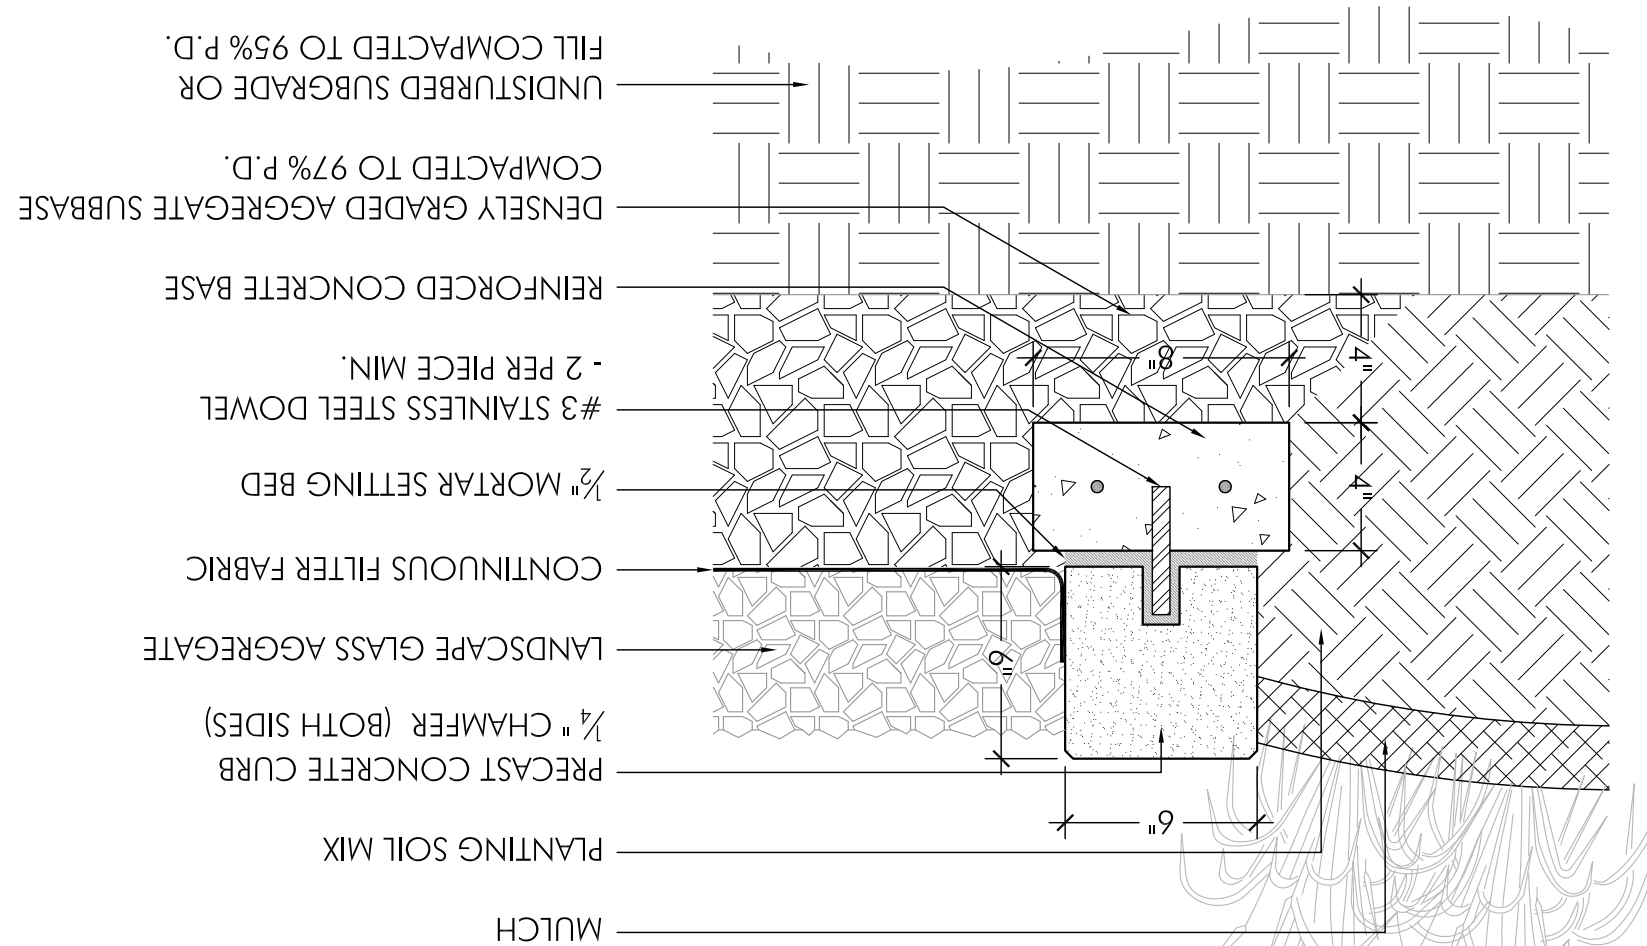



02
TRENCH DRAIN

SCALE : 1" = 1'-0"


- TRENCH DRAIN NOTES:
1. PROVIDE K100 PRE-SLOPED TRENCH DRAIN SYSTEM BY ACO USA
800.543.4764.
 2. CONTRACTOR TO PROVIDE SHOP DRAWINGS, BY ACO, OF TRENCH DRAINS FOR REVIEW BY PROJECT LANDSCAPE ARCHITECT PRIOR TO CONSTRUCTION.
 3. PROVIDE CAST IRON "OBULO HEELPROOF" GRATE BY IRONAGE DESIGNS 877.418.3568 - SEE SHEET L3.20.

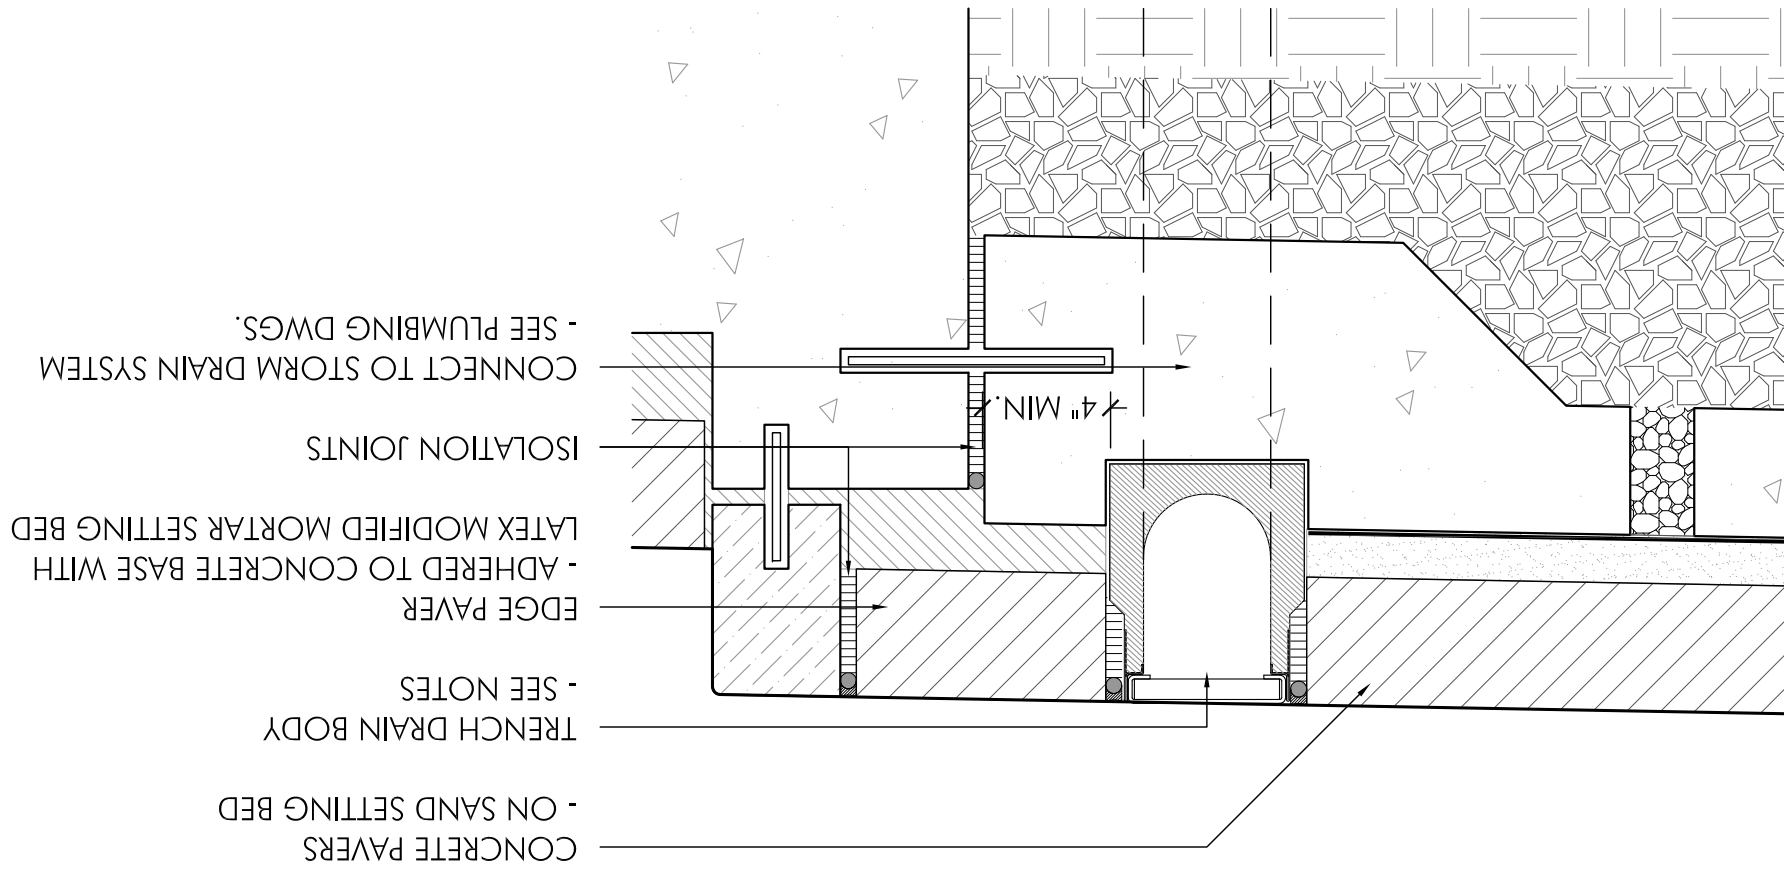

1. FABRICATOR TO PROVIDE SHOP DRAWINGS OF STAINLESS STEEL HANDRAILS. SHOP DRAWINGS SHALL INCLUDE LAYOUT, DIMENSIONS, ALL METHODS OF FASTENING, AND PRODUCT DATA FOR REVIEW AND APPROVAL OF PROJECT LANDSCAPE ARCHITECT PRIOR TO FABRICATION.
2. ALL HANDRAIL ELEMENTS TO MEET BUILDING CODES.
3. HANDRAIL POSTS, AND SUPPORTS TO BE TYPE 304 STAINLESS STEEL, #5 SATIN FINISH. SCH. 40 TUBULAR HANDRAIL.
4. ALL WELDS TO BE GROUND SMOOTH PRIOR TO FINISHING. FABRICATOR TO TAKE STEPS TO PREVENT CORROSION AT WELDS (PASSIVATION).

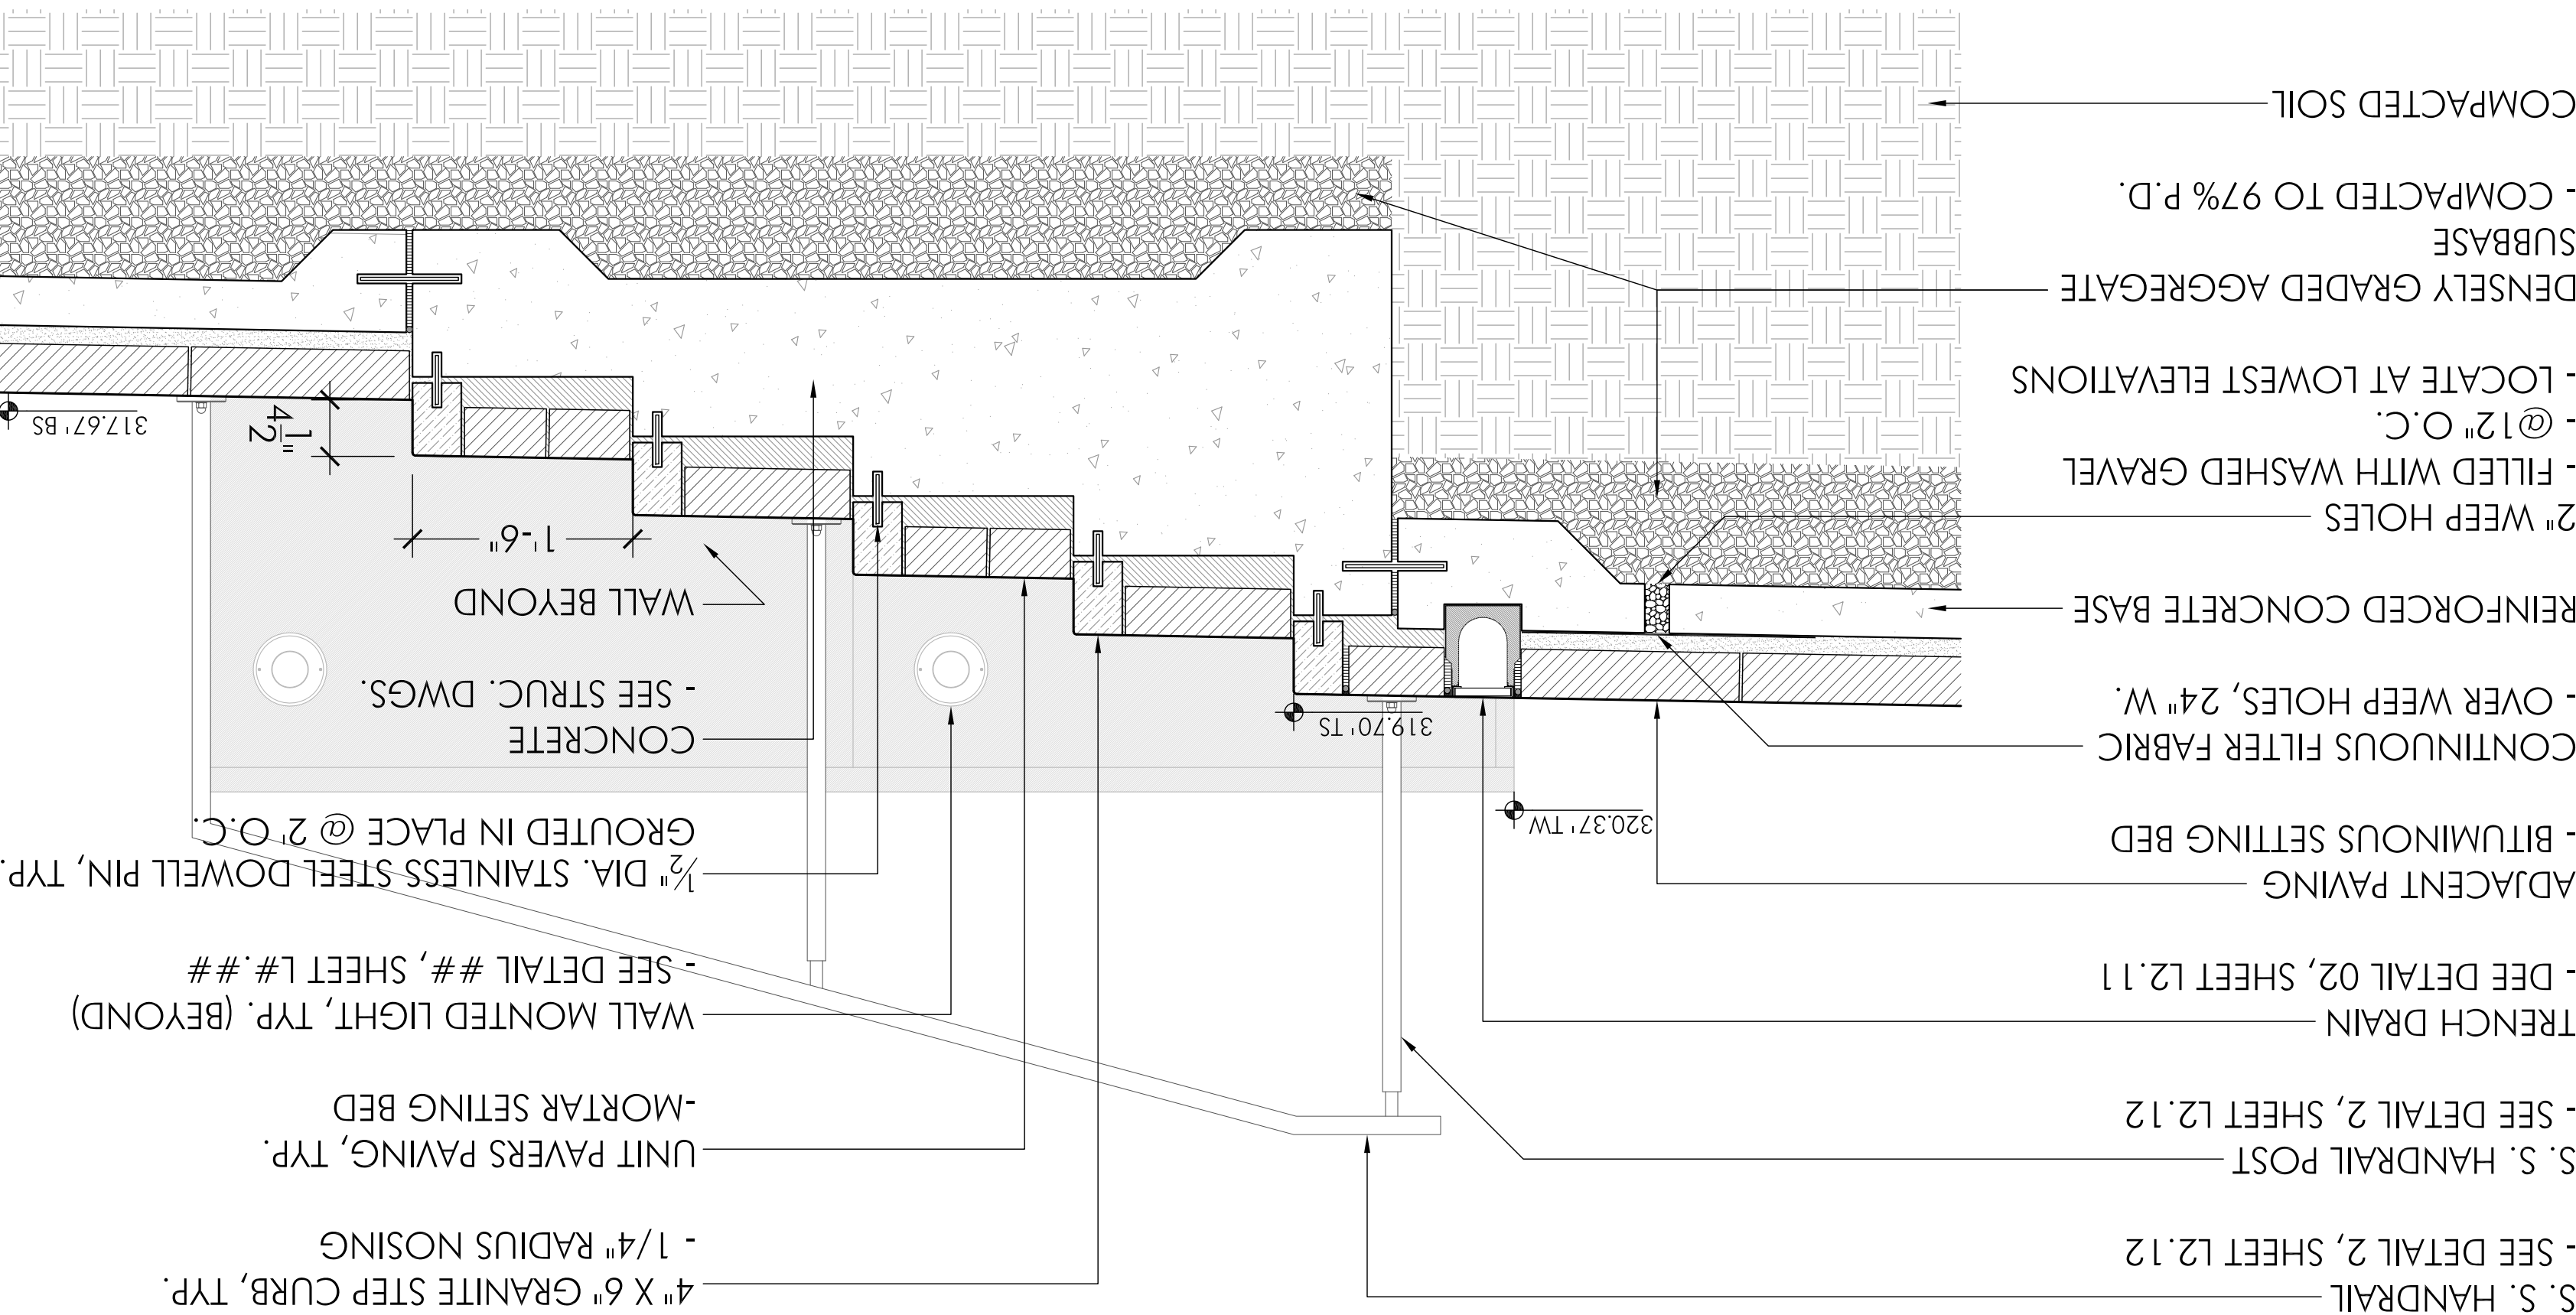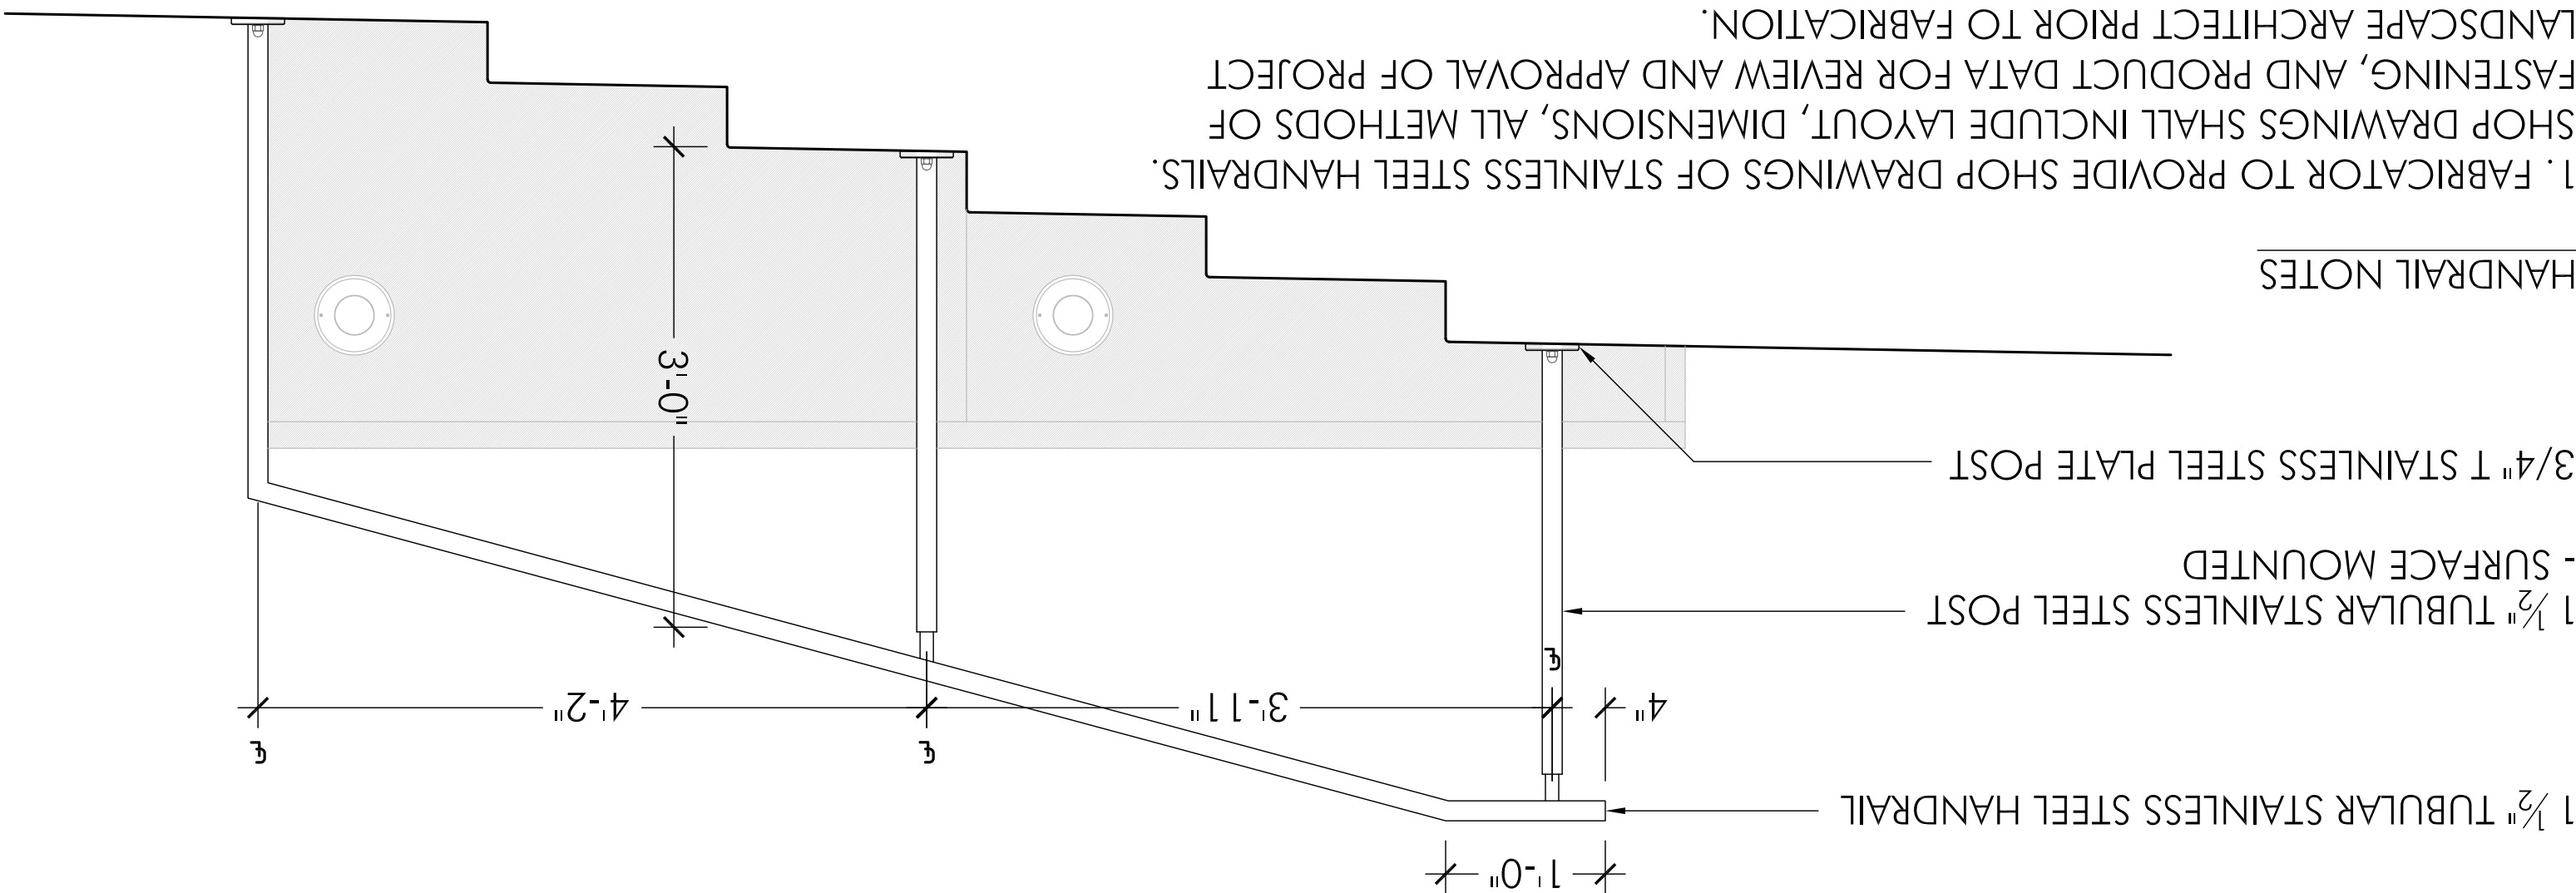

1. SEE STRUCTURAL ENGINEER'S DRAWINGS FOR CONCRETE REINFORCING INFORMATION.
2. STONE - PRODUCT INFORMATION:
- TYPE: MESA BI BLACK
- FINISH : DIAMOND 100
- MANUFACTURER: COLDSRING GRANITE (WWW.COLDSRINGUSA.COM)
3. PROVIDE A MIN. OF 4" OF STONE VENEER BELOW SOIL GRADE AND ON ALL ADJACENT PAVING.
4. CONTRACTOR TO PROVIDE SHOP DRAWINGS OF WALL PIECES INDICATING LAYOUT, CORNER DETAILS, ETC. FOR REVIEW AND APPROVAL BY PROJECT LANDSCAPE ARCHITECT PRIOR TO FABRICATION.
5. CONTRACTOR TO PROVIDE STONE AND JOINT SEALANT COLOR/FINISH SAMPLES FOR REVIEW AND APPROVAL BY PROJECT LANDSCAPE ARCHITECT PRIOR TO FABRICATION.

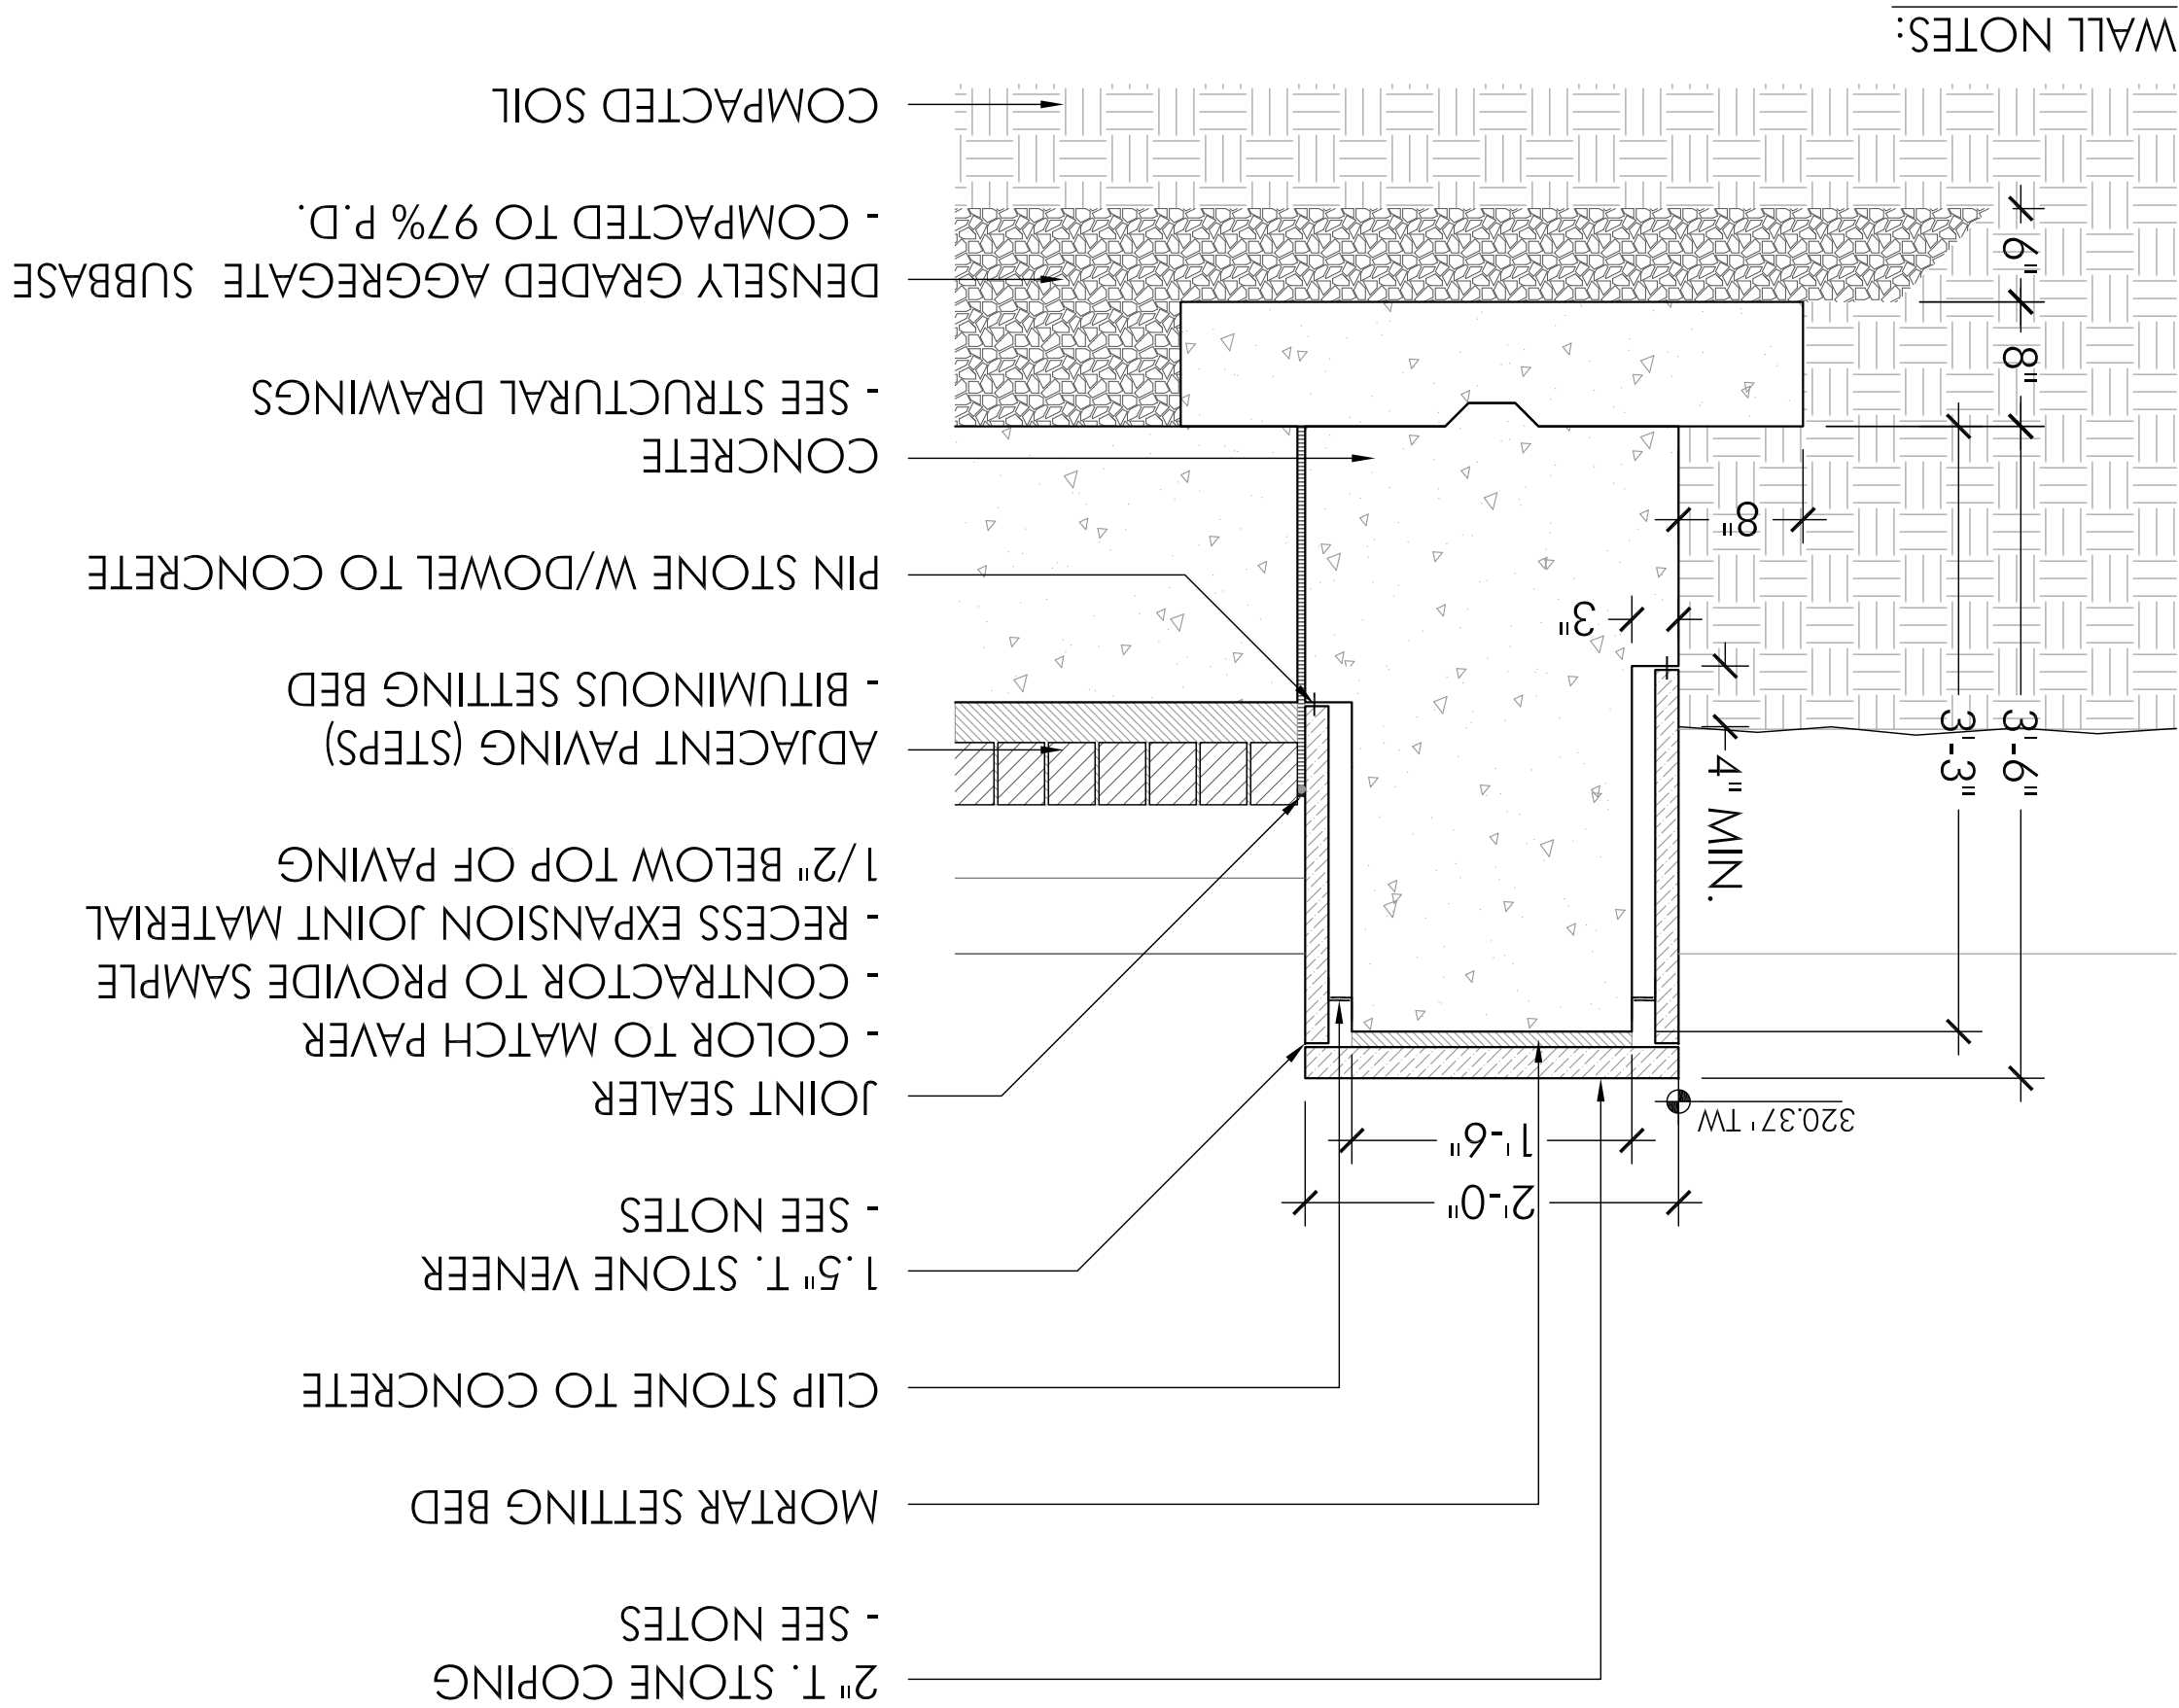

MONTGOMERY COUNTY PLANNING DEPARTMENT THE MARYLAND NATIONAL CAPITAL PARK AND PLANNING COMMISSION	
Chair or Designee	Date
Montgomery County Planning Board Certified Site Plan File No. 81983121A 09/16/13	
MANCPC APPROVAL STAMP	

DEVELOPER'S CERTIFICATE	
The undersigned agrees to execute all the features of the Site Plan Approval No. 81983121A, including Approval Conditions, Development Program, and Certified Site Plan.	
Developer's Name: 7811 Montrose LP/WILCO Co.	Contact Person: Robert Mazurka
Company: WILCO Companies - 7811 Montrose Road - Potomac, MD 20854	Address: WILCO Companies - 7811 Montrose Road - Potomac, MD 20854
Phone: (240) 399-1421	Signature:

PLANTING	
(6) CANOPY TREES Gleditsia thacanthos (Honey Locust)	
(9) SHADE TREES Carpinus caroliniana (American Hornbeam)	
(3) ORNAMENTAL TREES Magnolia stellata (Star Magnolia)	
Shrubs	
Perennials	
Bulbs	
Groundcovers	

LEGEND

QTY	KEY	BOTANICAL NAME	COMMON NAME	SIZE	COND.	COMMENTS
9	CC	Carpinus caroliniana	American Hornbeam	8-10' ht.	B&B	single stem; full branching
6	GT	Gleditsia thacanthos	Honey Locust	3-3 1/2' col.	B&B	single leader; full branching
3	MS	Magnolia stellata	Star Magnolia	7-8' ht.	B&B	multistem - 3 stems minimum; full branching
Evergreen Shrubs						
27	IS	Ilex crenata 'Sheela'	Sheela Japanese Holly	30"-36" ht.	Cont.	full branching to ground
50	BS	Buxus sempervirens 'Suffruticosa'	Dwarf English Boxwood	24-30" ht.	Cont.	full branching to ground
57	PL	Prunus laurocerasus 'Chio Luykensis'	Chio Luykensis Cherry Laurel	24-30" ht.	B&B	full branching;
12	RD	Rhododendron 'Delaware Valley White'	White Azalea	24-30" ht.	Cont.	full branching;
Perennials						
20	LSK	Liatris spicata	Gayleather	1 gal.	Cont.	24" o.c.; accent
90	SNM	Salvia nemerosa 'Manocho'	May Night Salvia	1 gal.	Cont.	12" o.c.; accent
100	NTE	Nassella tenuissima	Mexican Feather Grass	2 gal.	Cont.	24" o.c.
340	HCA	Hypanthium capyricum	St. John's Wort	1 gal.	Cont.	18" o.c.
Bulbs						
780	SAT	Saxifraga ovum-nalis	Autumn Moor Grass	1 gal.	Cont.	18" o.c. - fully rooted; grown to pot size
30	AGI	Allium giganteum	Ornamental Onion	bulbs	accent	
290	NAR	Narcissus 'Thalia', 'Silver Chimes', 'Tresomble'	White Daffodils mixture	bulbs	accent	

DEVELOPER'S CERTIFICATE

The undersigned agrees to execute all the features of the Site Plan Approval No. 81983121A, including Approval Conditions, Development Program, and Certified Site Plan.


Developer's Name: 7811 Montrose LP/WillCO Co. Robert Mazzuca
Company/Contact Person
Address: WillCO Companies - 7811 Montrose Road - Potomac, MD 20854
Phone: (240) 399-1421

Signature: _____


MANPCPC APPROVAL STAMP

Montgomery County Planning Board
File No. 81983121A.
Certified Site Plan
1"-10'-0"

Chair or Designee
Date

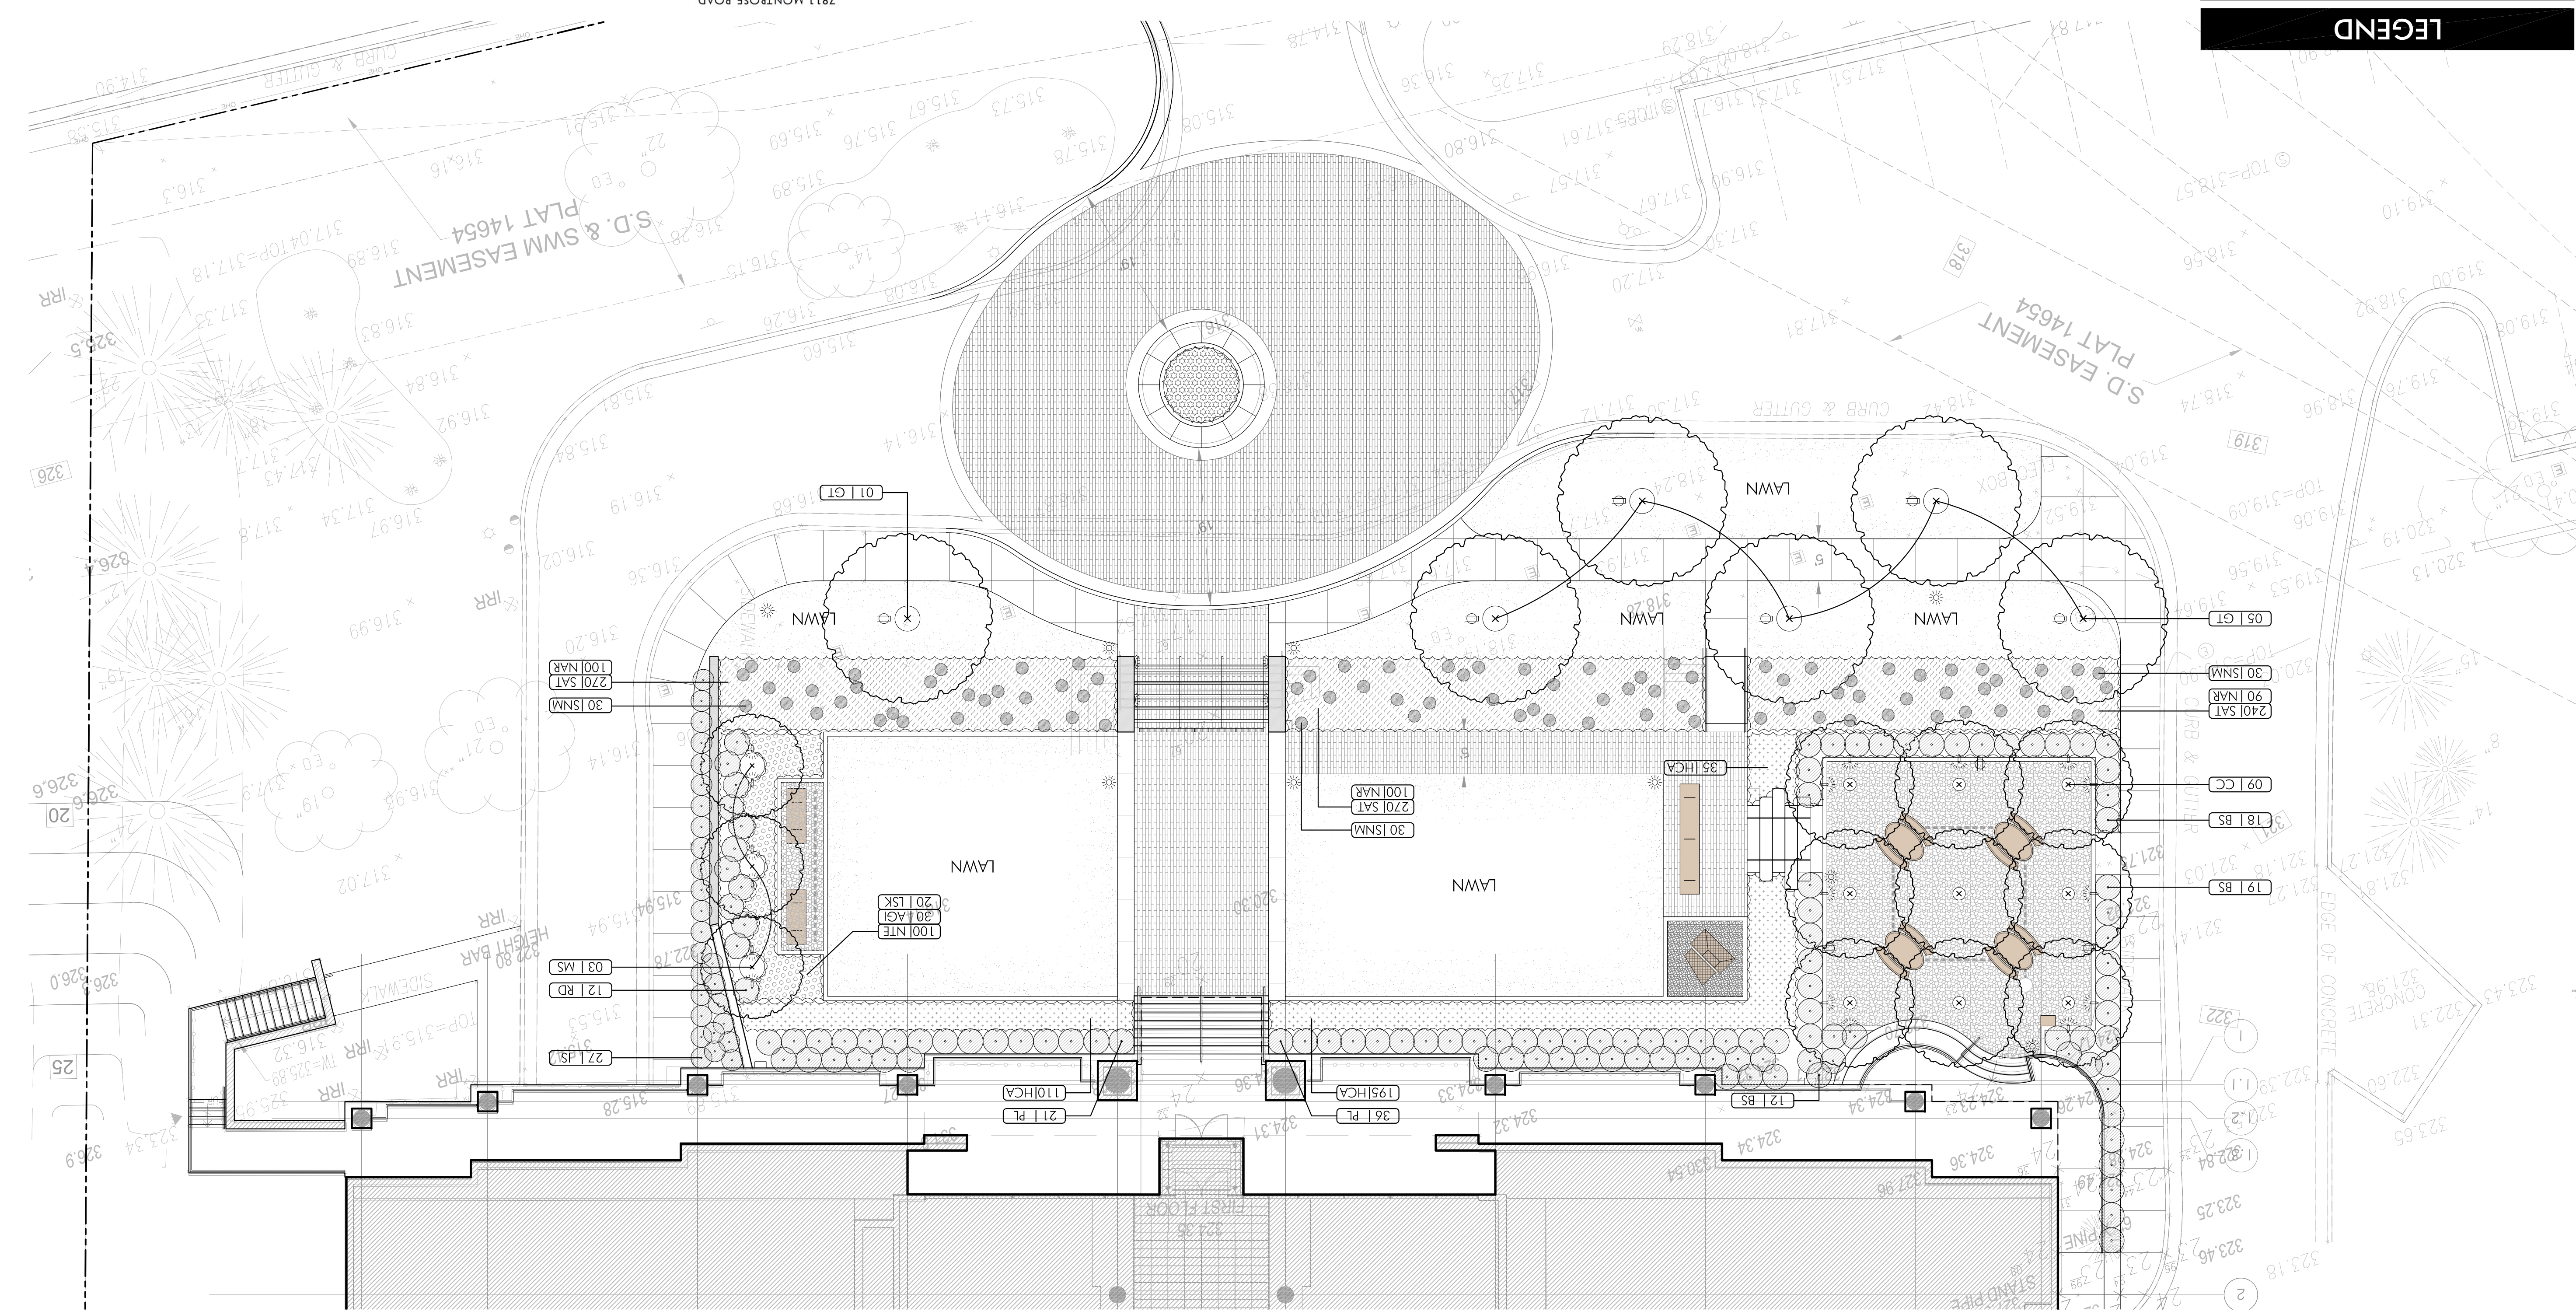


13.00

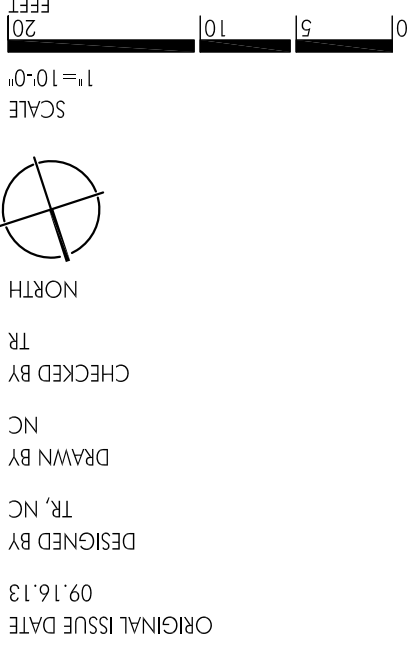

PLANTING PLAN



REVISIONS	09/16/13	DESIGN DEVELOPMENT SET	10/15/13
	11/14/13	BID SET	11/14/13

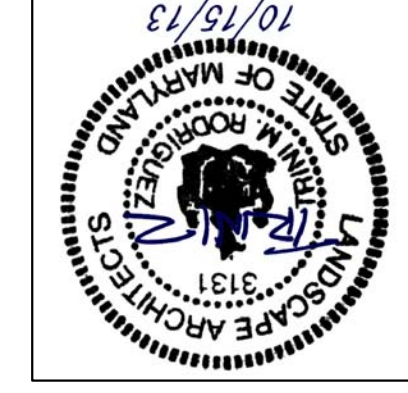


PARKER RODRIGUEZ, INC.
MONTGOMERY COUNTY, MD
POTOMAC
101 North Union St. #320
Arlington, VA 22214
703.548.5010
OWNER
WILLCO Companies
7811 Montrose Road
Suite 500
Potomac, MD 20854
ARCHITECT
WDC Architecture
1025 Connecticut Avenue NW
Suite 300
Washington, DC 20006
CML ENGINEER
Johnson, Berndt, Associates, Inc.
205 North Frederick Avenue
Suite 100
Gaithersburg, MD 20877
301.963.1133

7811 MONTROSE ROAD

- LEGEND
- BUSH
 - GROUND SHOT
 - SIGN
 - FIRE HYDRANT
 - IRRIGATION VALVE
 - WATER VALVE
 - SIGNAL POLE
 - STORM MH
 - SANITARY MH
 - GAS VALVE
 - GROUND LIGHT
 - ELEC. BOX
 - ELEC. MH
 - GUY WIRE
 - LIGHT POLE
 - POWER POLE
 - ELEC. OUTLET
 - TRASH CAN
 - BOLLARD
 - CURB & GUTTER
 - OVERHEAD ELEC.
 - DRAIN
 - EX. TREE

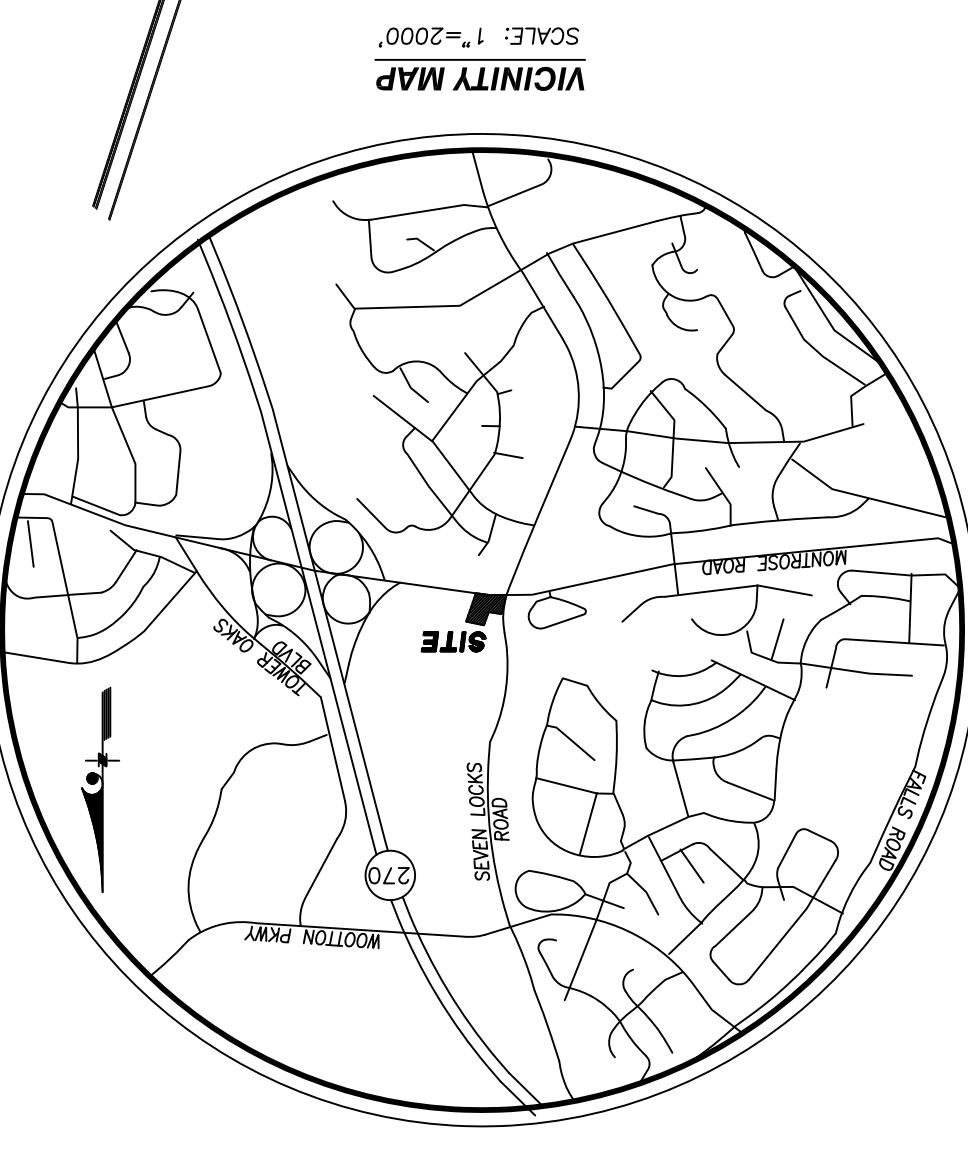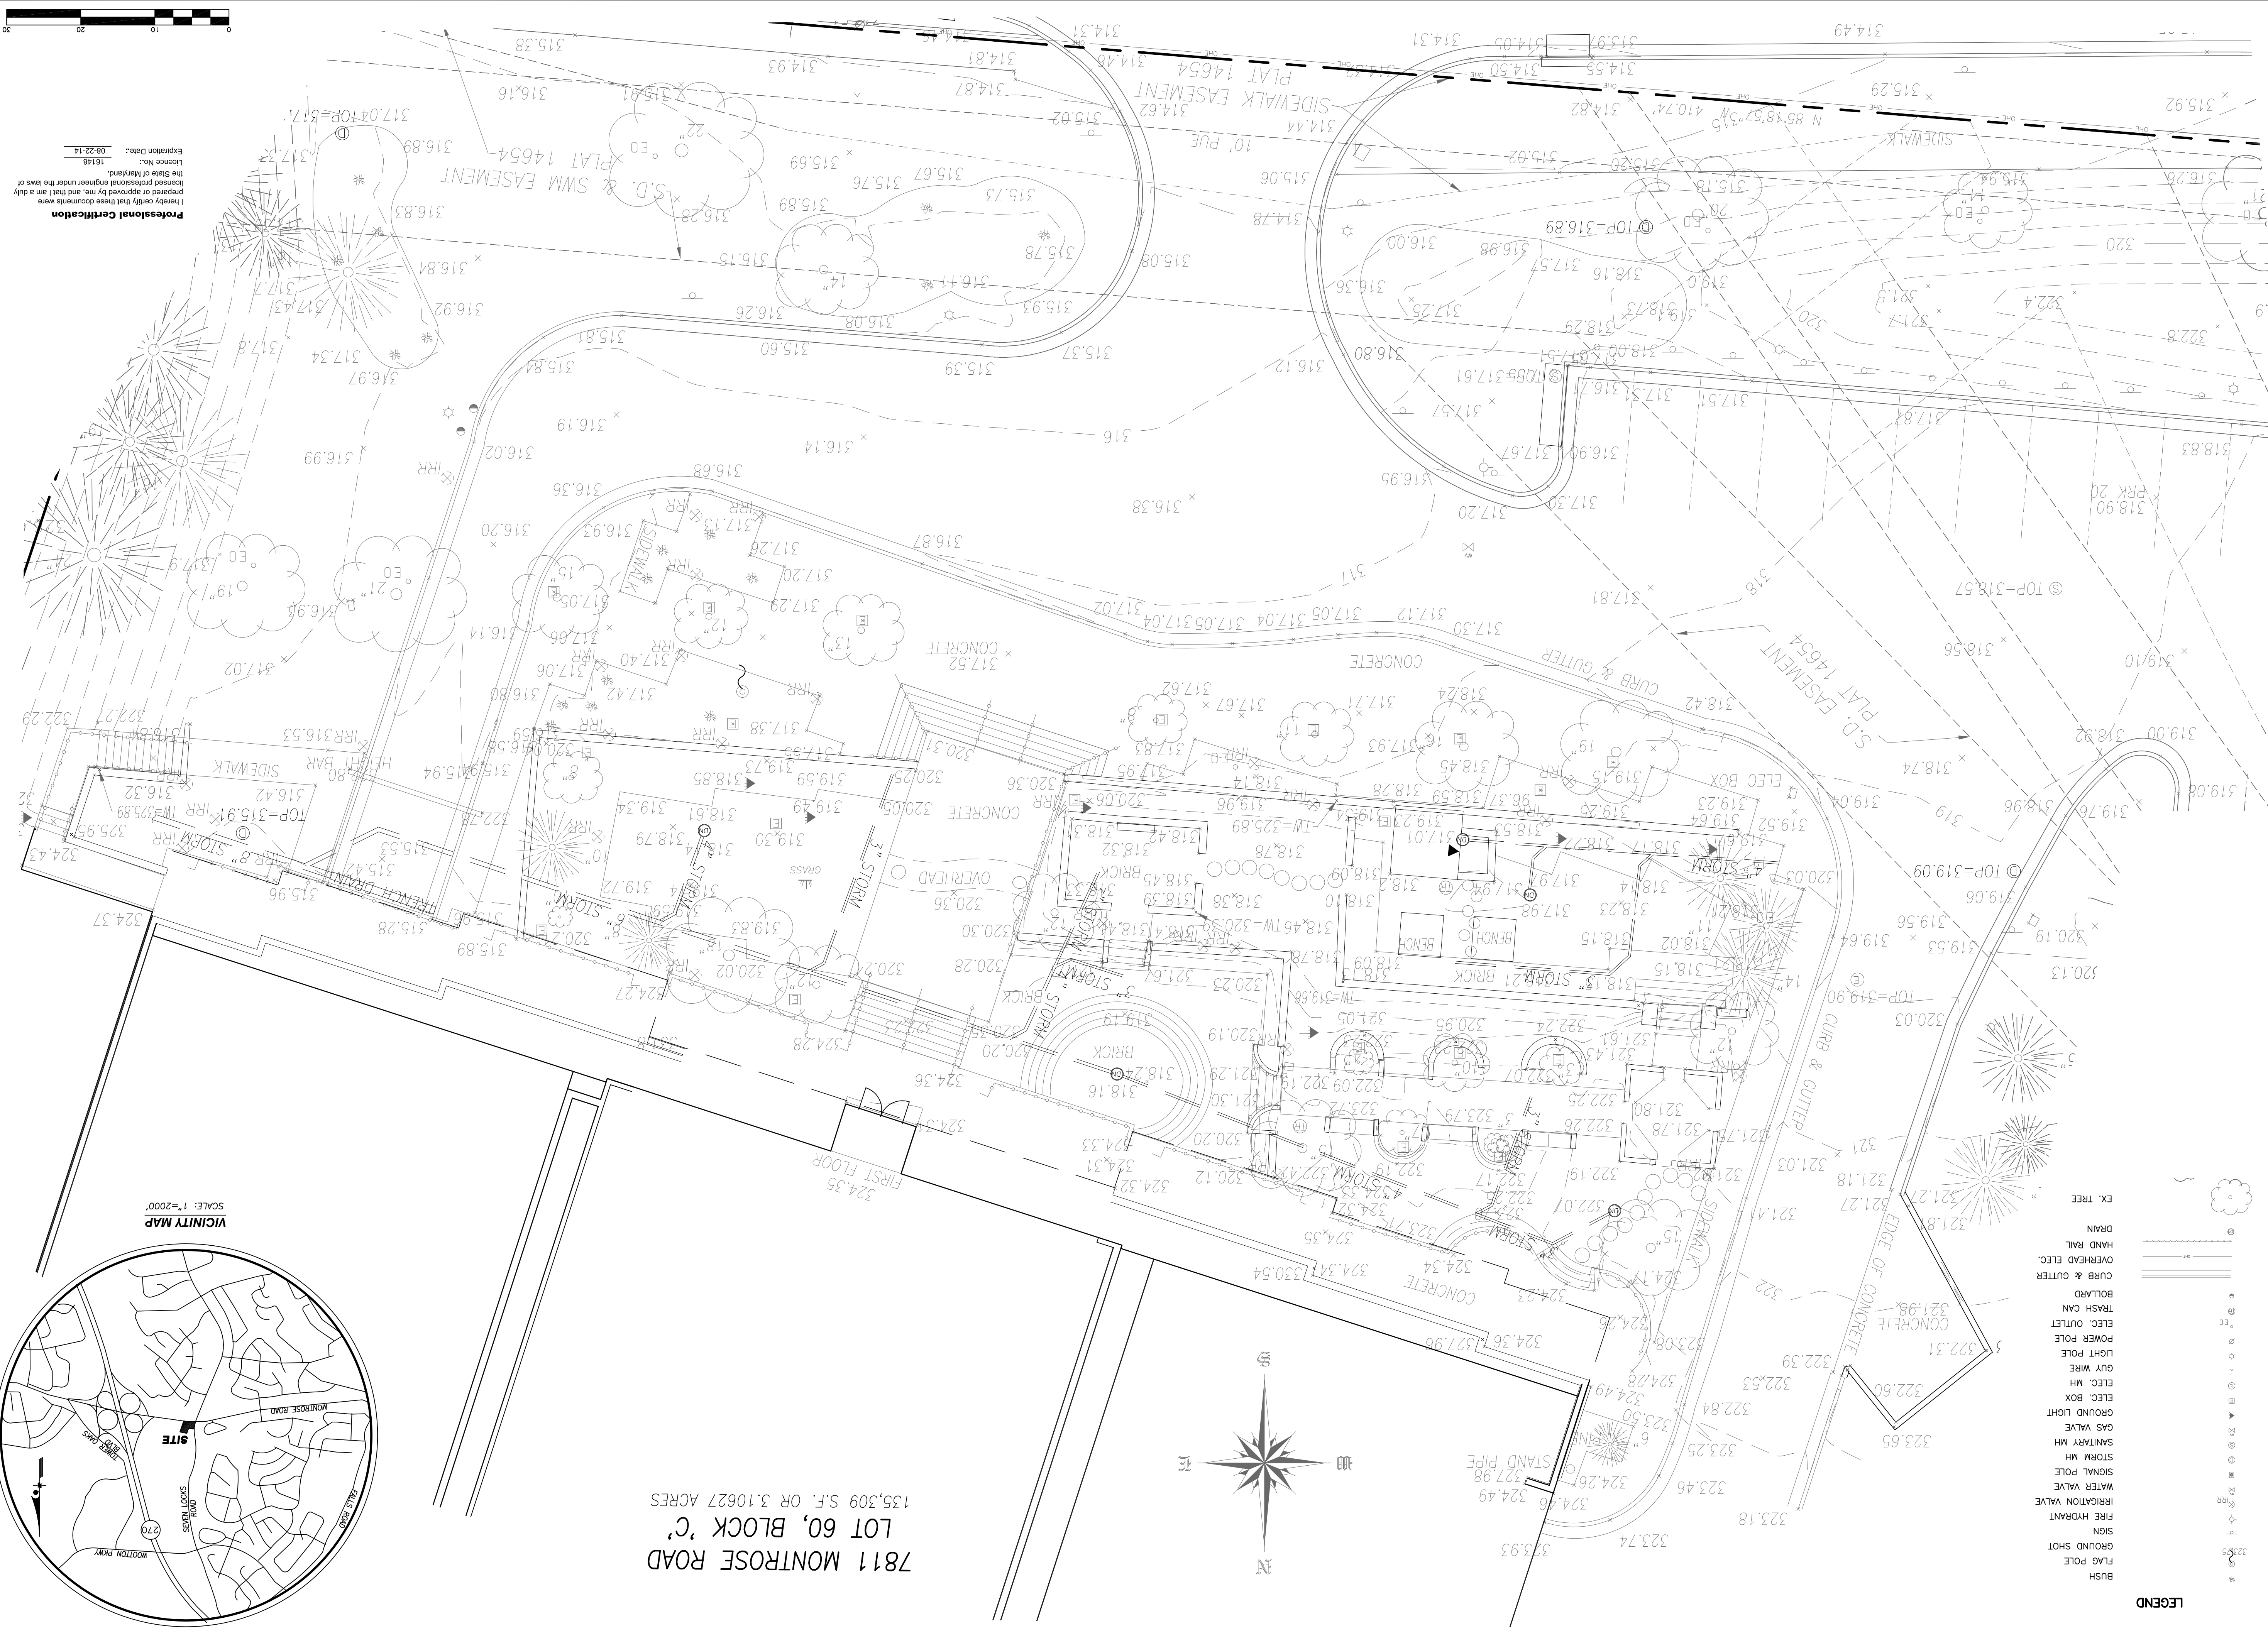

7811 MONTROSE ROAD
LOT 60, BLOCK 'C'
135,309 S.F. OR 3.10627 ACRES

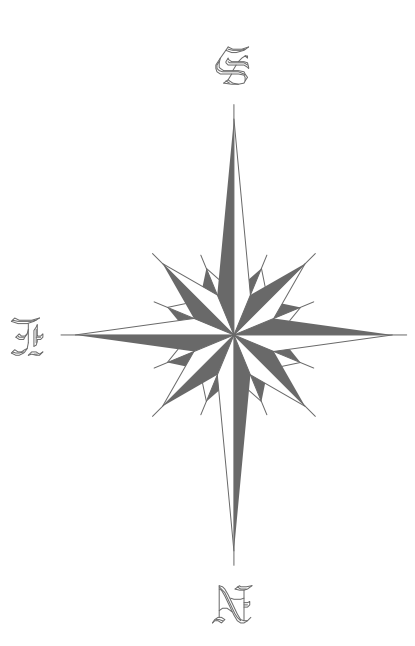




Professional Certification
I hereby certify that these documents were prepared or approved by me, and that I am a duly licensed professional engineer under the laws of the State of Maryland.
License No.: 16149
Expiration Date: 06-23-14

PLAN NO.:
SCALE: 1"=10'
DATE: 11/1/13
SHEET: C-1.01
FILE NO: 13-017

7811 MONTROSE ROAD
EXISTING CONDITIONS PLAN
POTOMAC, MARYLAND

REV.	DATE	REVISIONS PRIOR TO APPROVAL

  J.B.A.
Johnson • Bernat • Associates, Inc.
205 N. Frederick Ave. S. 100
Gaithersburg, MD 20877
Tel: (301) 963-1133
Fax: (301) 963-6306
www.jba-inc.net

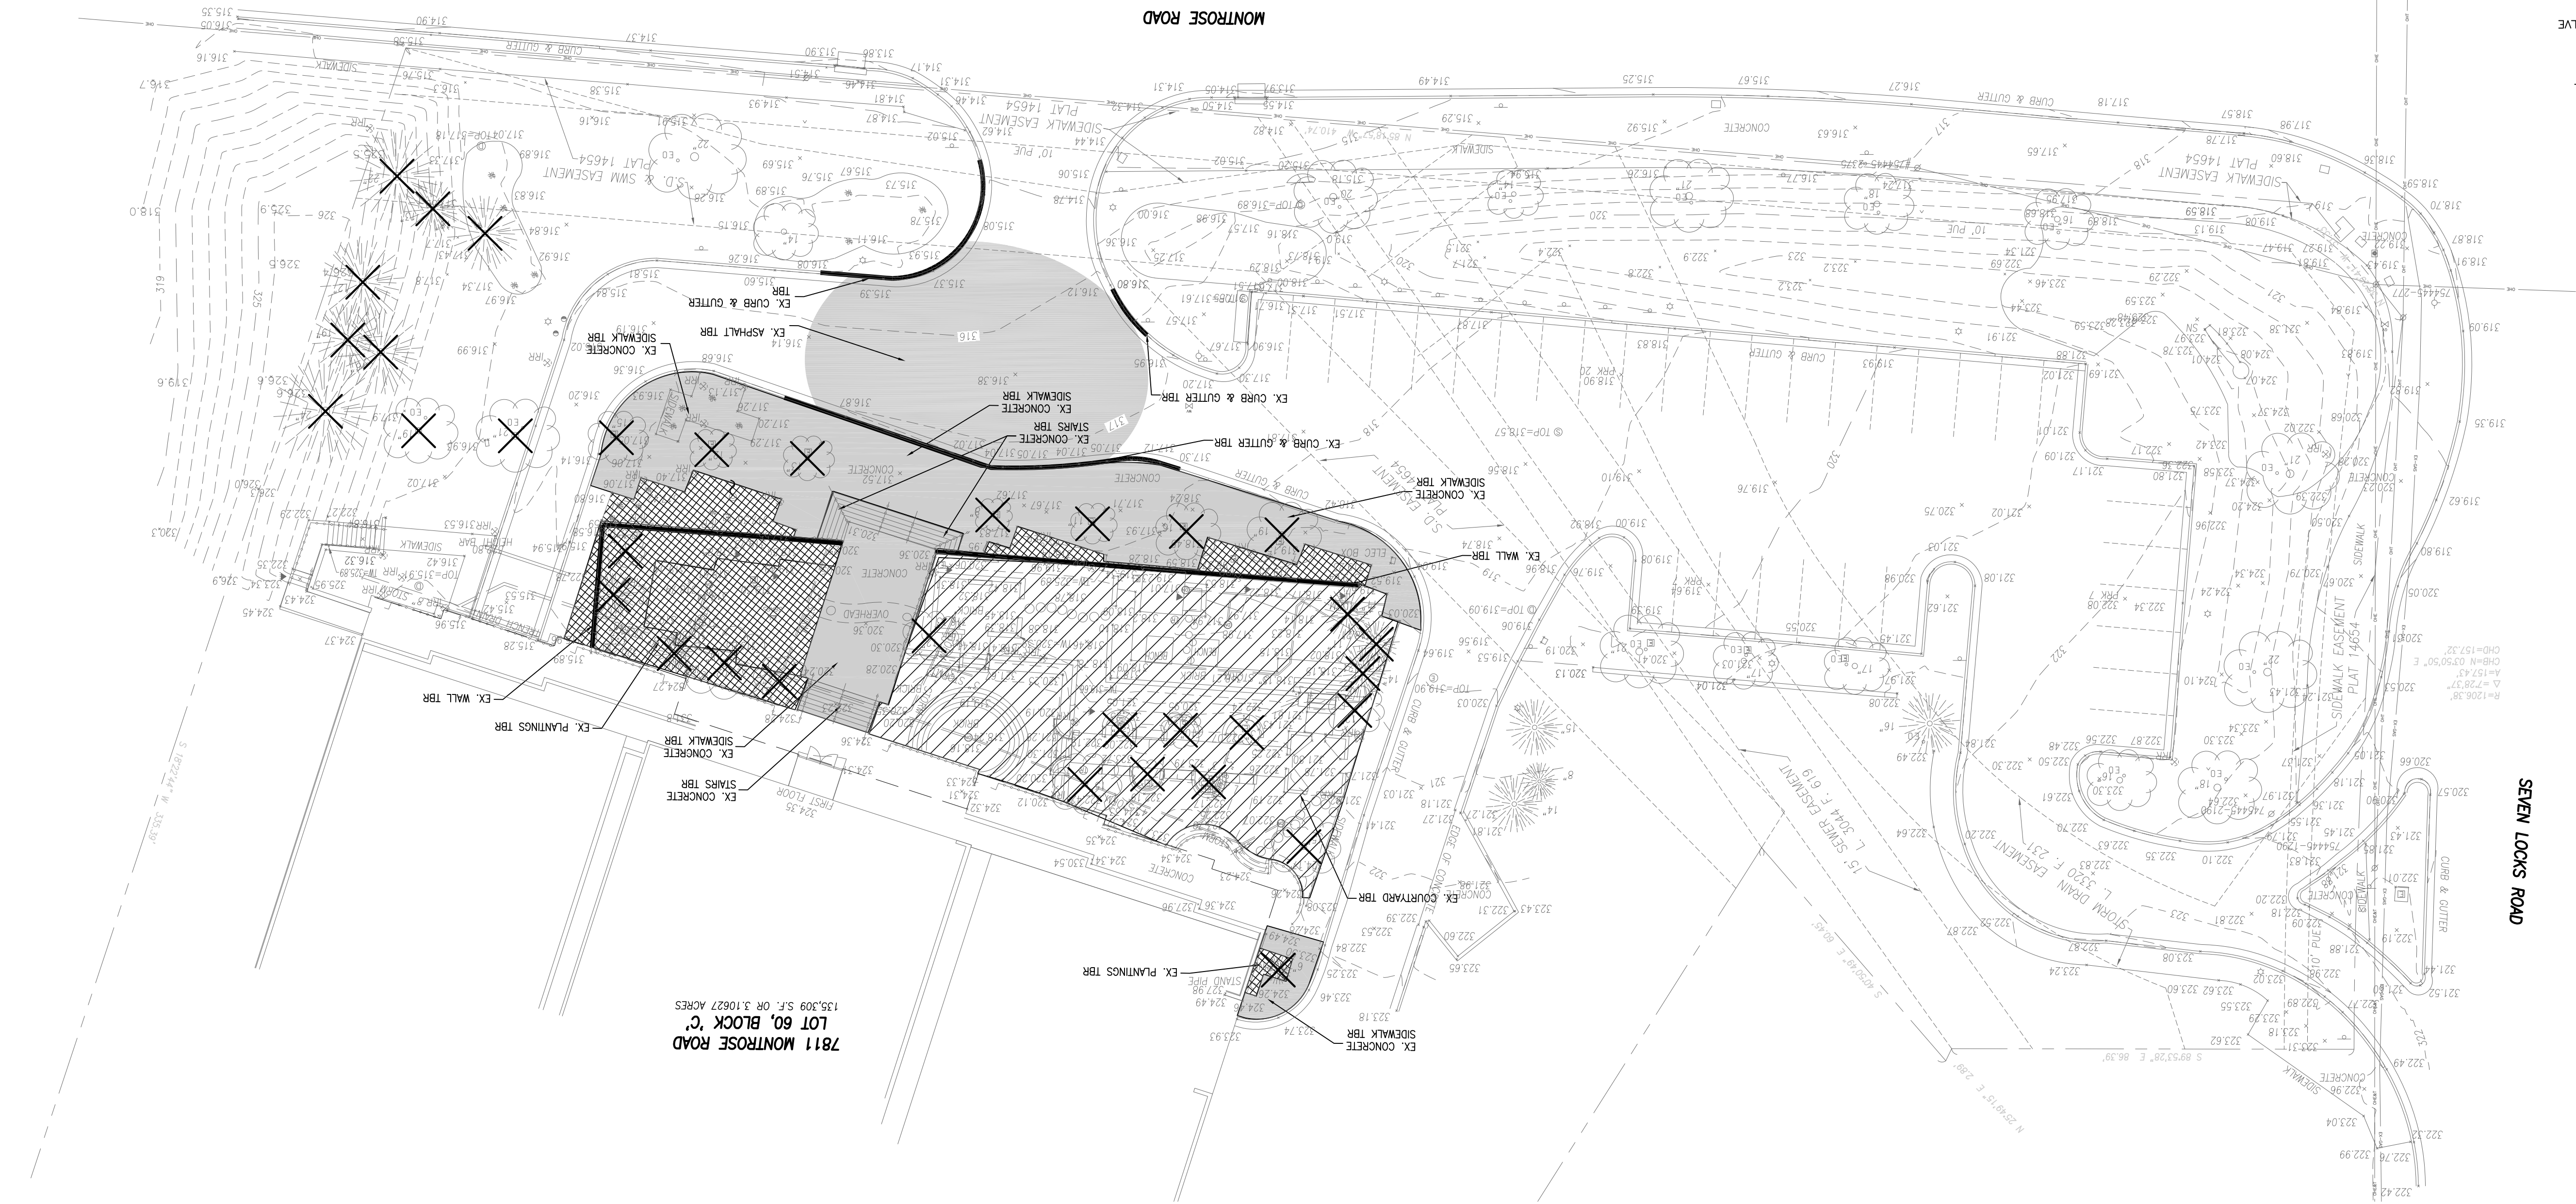

1 MONTROSE R
DEMOLITION PLAN
POTOMAC, MARYLAND

REVISIONS PRIOR TO APPROVAL

J.B.A.
Johnson • Bernat • Associates, Inc.
205 N. Frederick Ave., S. 100
Gaithersburg, MD 20877
Tel. (301) 963-1133
Fax: (301) 963-6306
www.jba-inc.net
Engineering • Surveying • Planning

PLUMBING SPECIFICATIONS

1. ALL WORK SHALL BE IN ACCORDANCE WITH LOCAL CODES.

2. THESE DRAWINGS ARE SCHEMATIC AND INTENDED TO DEPICT THE GENERAL LOCATION OF PLUMBING SYSTEMS COMPONENTS. CONSULT ARCHITECTURAL PLANS FOR PROPER DIMENSIONS AND LOCATION OF FIXTURES.

3. PROVIDE ALL NECESSARY TRANSITIONS IN PIPING FOR COMPLETE INSTALLATION. NOT ALL OFFSETS ARE SHOWN ON THE DRAWINGS. ALL PIPING AND ACCESSORIES SHALL BE FULL SIZE AND REDUCED IN SIZE ONLY IMMEDIATELY BEFORE THE CONNECTION POINT TO THE EQUIPMENT.

4. FREE ACCESS IS REQUIRED ON ALL SIDES OF EQUIPMENT. ALL SUCH EQUIPMENT SHALL BE LOCATED AS TO PROVIDE ADEQUATE SERVICE CLEARANCE AND AS REQUIRED TO MEET THE CLEARANCES REQUIRED BY THE NATIONAL ELECTRIC CODE (NEC).

5. PIPE HANGERS FOR ALL PLUMBING PIPING SHALL BE CLEWS TYPE OF THE SAME MATERIAL AS ASSOCIATED PIPING. PIPING HANGERS SHALL BE INSTALLED AT 5 FOOT INTERVALS AND AT BOTH SEGMENTS OF ALL DIRECTION CHANGES.

6. THIS PROJECT SHALL HAVE A WET PIPE SPRINKLER SYSTEM DESIGNED IN ACCORDANCE WITH NFPA 13 AND THE COUNTY REQUIREMENTS.

A. TENANT SPACE IS CURRENTLY SPRINKLED. EXTEND EXISTING WET PIPE SPRINKLER SYSTEM FROM EXISTING MAIN TO TENANT SPACE AND THROUGHOUT AS REQUIRED BY NEW TENANT LAYOUT. COORDINATE SPRINKLER HEADS SO THAT NO HEADS ARE LOCATED WITHIN NEW WALLS AND SPRINKLER COVERAGE IS MAINTAINED. SPRINKLER HEADS SHALL BE LOCATED IN THE CENTER OR ALL CEILING TILES. ADD AND RELOCATE SPRINKLER HEADS TO PROPERLY PROTECT THE TENANT SPACE PER THE BASE BUILDING DESIGN AND CONFIGURATION.



B. NEW MATERIALS TO MATCH BASE BUILDING STANDARD. INSTALLATIONS TO COMPLY WITH NFPA 13 AND MONTGOMERY COUNTY CODES AND REGULATIONS.

C. SPRINKLER CONTRACTOR SHALL PREPARE SHOP DRAWINGS AND SUBMIT THEM TO THE FIRE MARSHAL AND OBTAIN APPROVAL BEFORE START OF WORK. OBTAIN ARCHITECTS APPROVAL PRIOR TO SUBMITTING DRAWINGS TO FIRE MARSHAL.

D. UPON COMPLETION OF THE INSTALLATION, THE ENTIRE SYSTEM SHALL BE TESTED AND APPROPRIATE CERTIFICATES GIVEN TO THE OWNER.

E. PROVIDE PIPE HANGERS AND SUPPORTS AS REQUIRED.

F. SPRINKLER HEADS AND HANGERS TO BE UL AND FM APPROVED. NEW SPRINKLER HEADS TO MATCH BUILDING STANDARD. SPRINKLER PLACEMENT TO BE CENTER OF CEILING TILES, OR AS APPROVED BY THE LANDLORD.

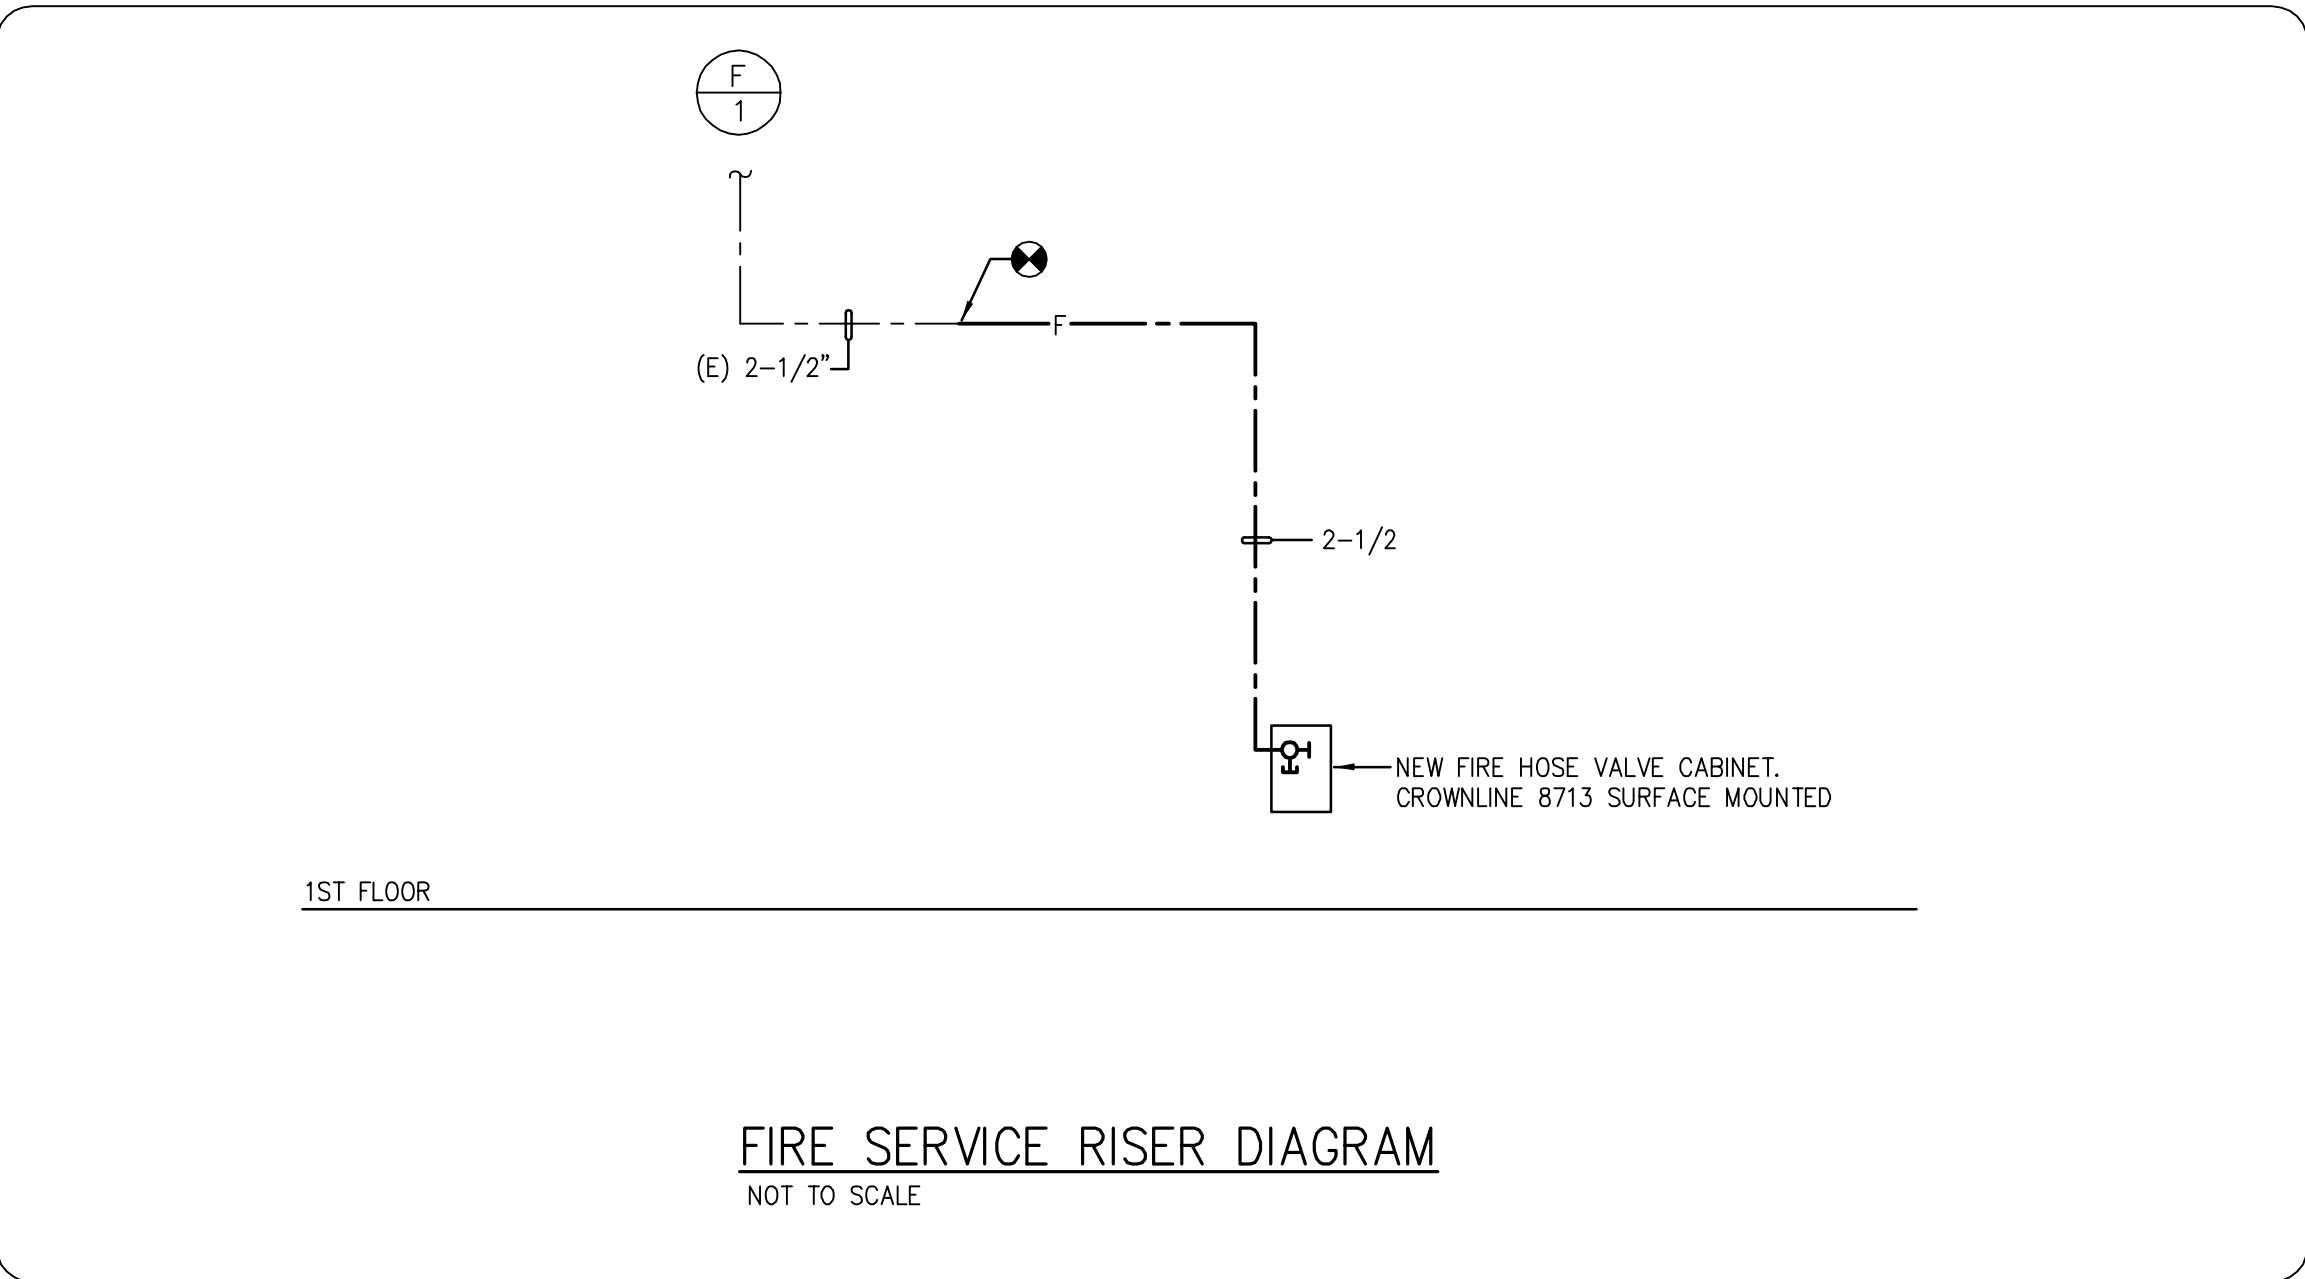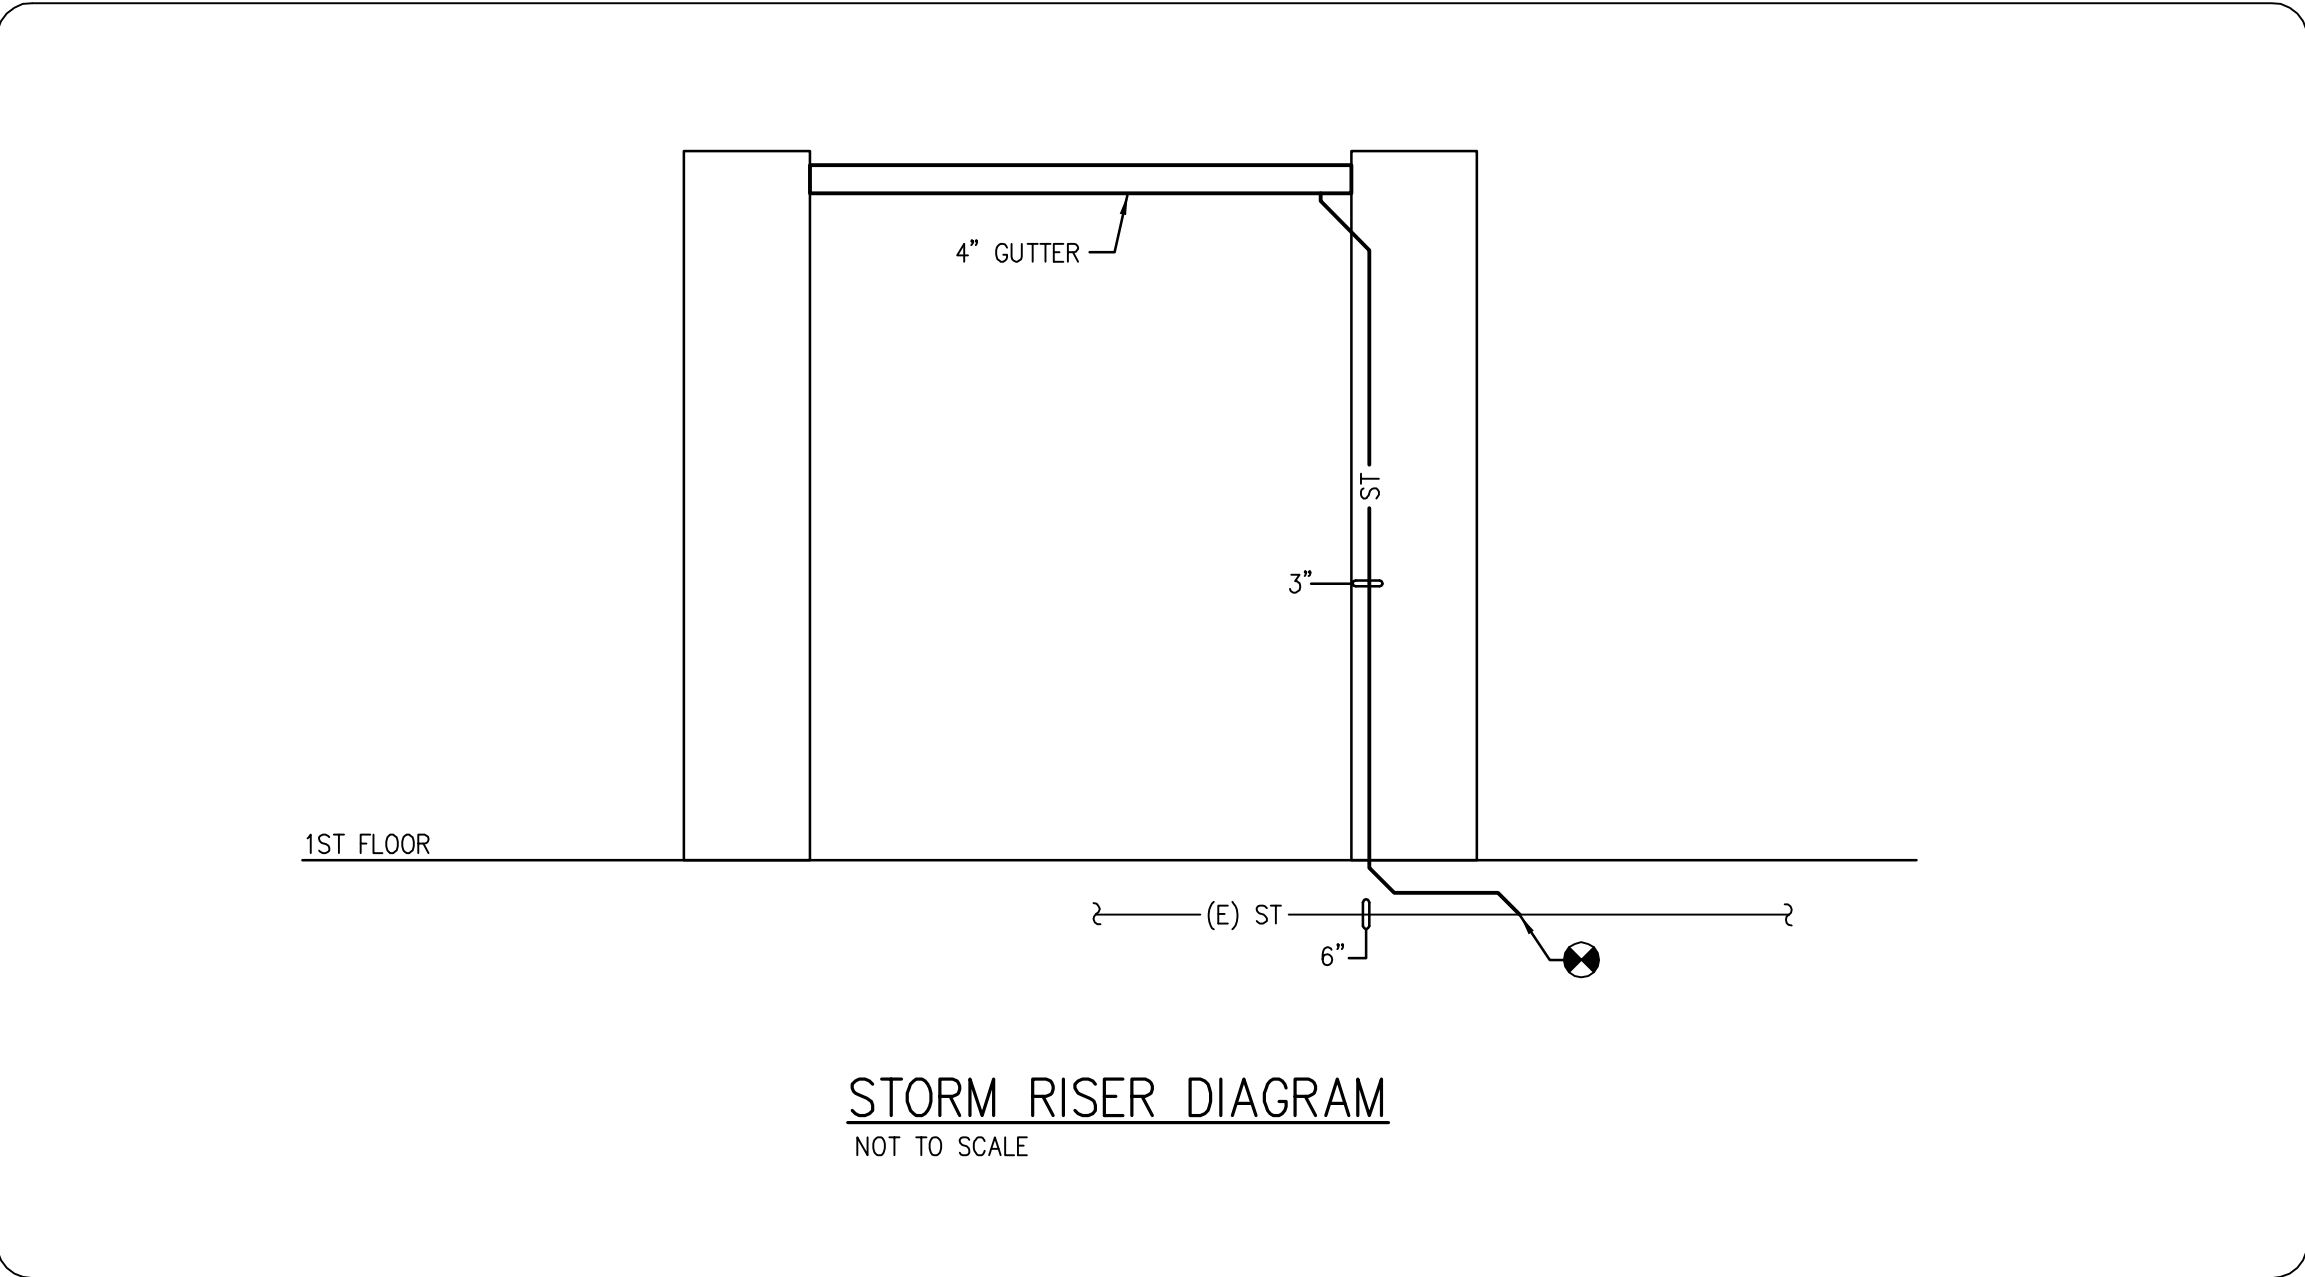

PLUMBING ABBREVIATIONS

BFP

BACKFLOW PREVENTER

CW

COLD WATER

(E)

EXISTING

HW

HOT WATER

SAN

SANITARY

ST

STORM

TYP

TYPICAL

V

VENT

PLUMBING SYMBOLS

ST

STORM PIPING

F

SPRINKLER PIPING

PIPE TURNING DOWN

PIPE TURNING UP

PIPE CONTINUING

PLUMBING NOTE DESIGNATION

NEW TO EXISTING DESIGNATION

LIMIT OF DEMOLITION

WDG Architecture, PLLC
1025 Connecticut Avenue NW
Suite 300
Washington DC 20036
tel 202 857 8300
fax 202 463 2198
e-mail wdg@wdgarch.com

Structural
Tadler-Cohen-Edelson
Associates
1109 Spring Street
Suite 510
Silver Spring, MD 20910
tel (301) 587-1820
fax (301) 588-1966
e-mail tadlerco.com

MEP
WFT Engineering, Inc.
9737 Washingtonian Boulevard
Suite 588
Gaithersburg, MD 20878
tel (301) 230-0811
fax (301) 330-8911
e-mail wfteng.com
wft job number 13074

7811 MONTROSE RD
POTOMAC, MD

WILLCO
Companies
7811 Montrose Road
Suite 500
Potomac, MD 20854

PERMIT SUBMISSION 10/15/13


Professional Seal

© 2012 WDG Project No: WA11042


PLUMBING SPECIFICATIONS, SYMBOLS, RISERS & ABBREVIATIONS

Scale: AS NOTED


P-1

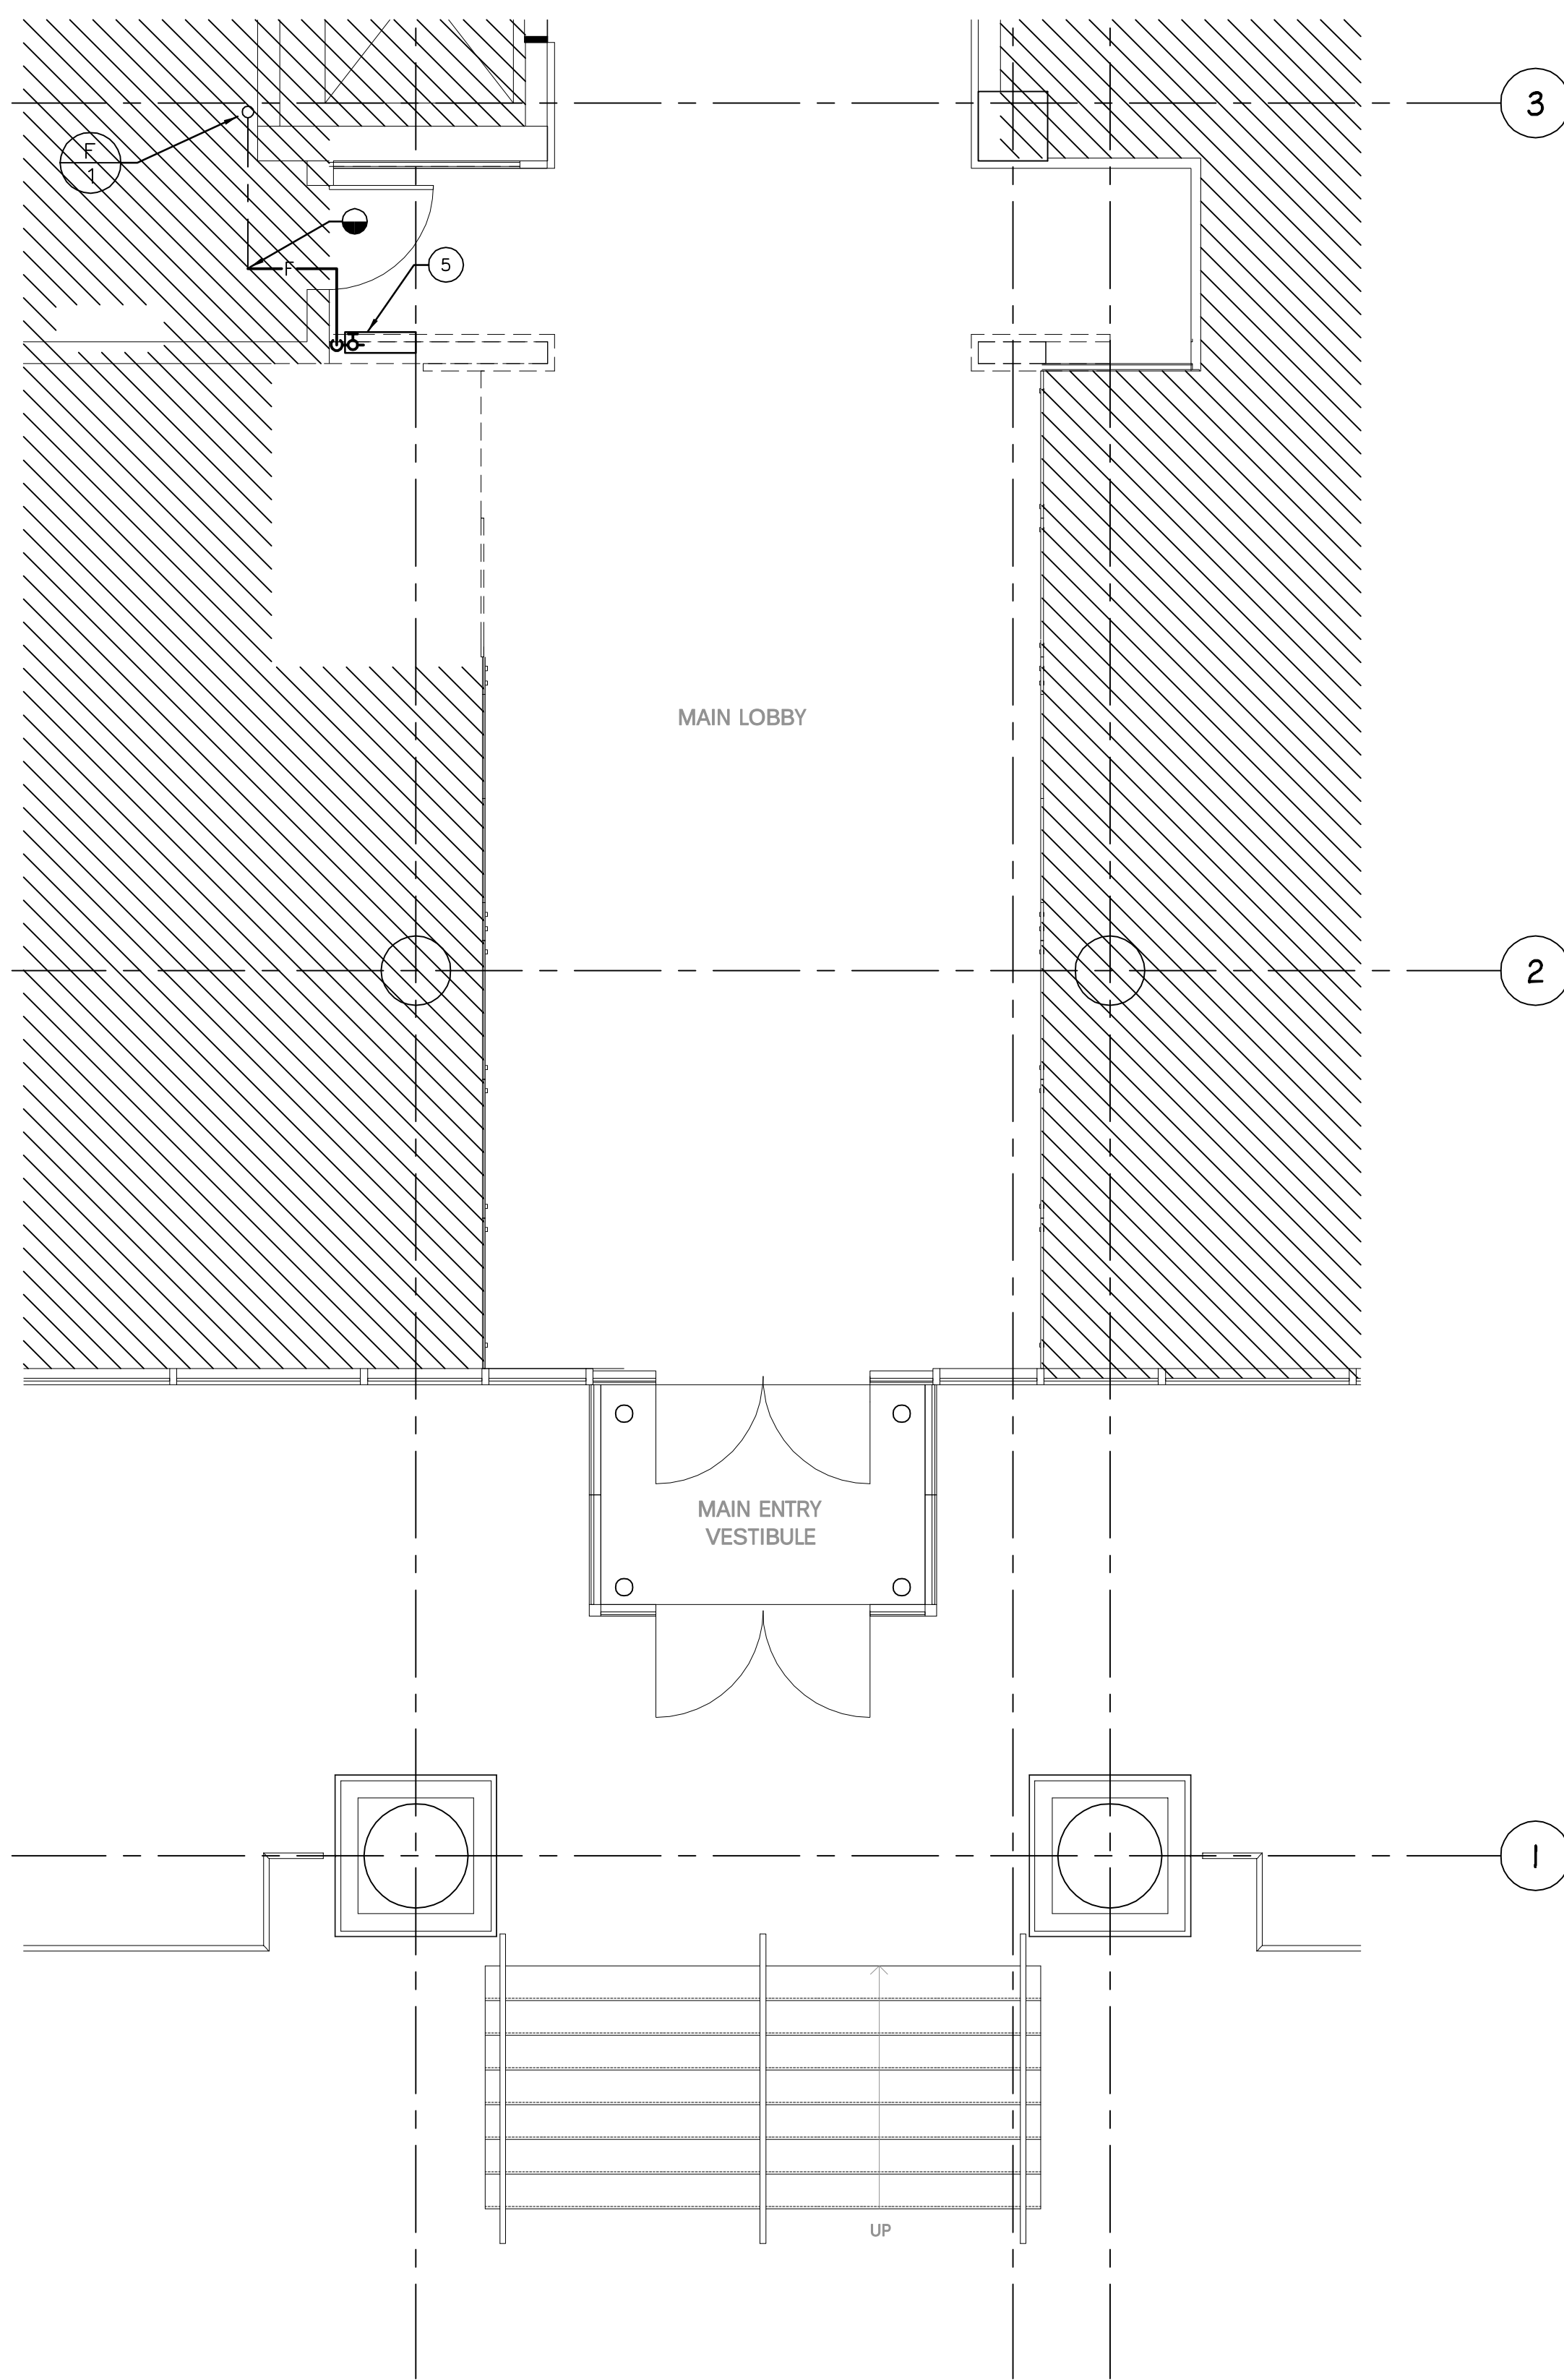

PARTIAL FIRST FLOOR PLAN – DEMOLITION ①②③④
SCALE: 1/4"=1'-0"

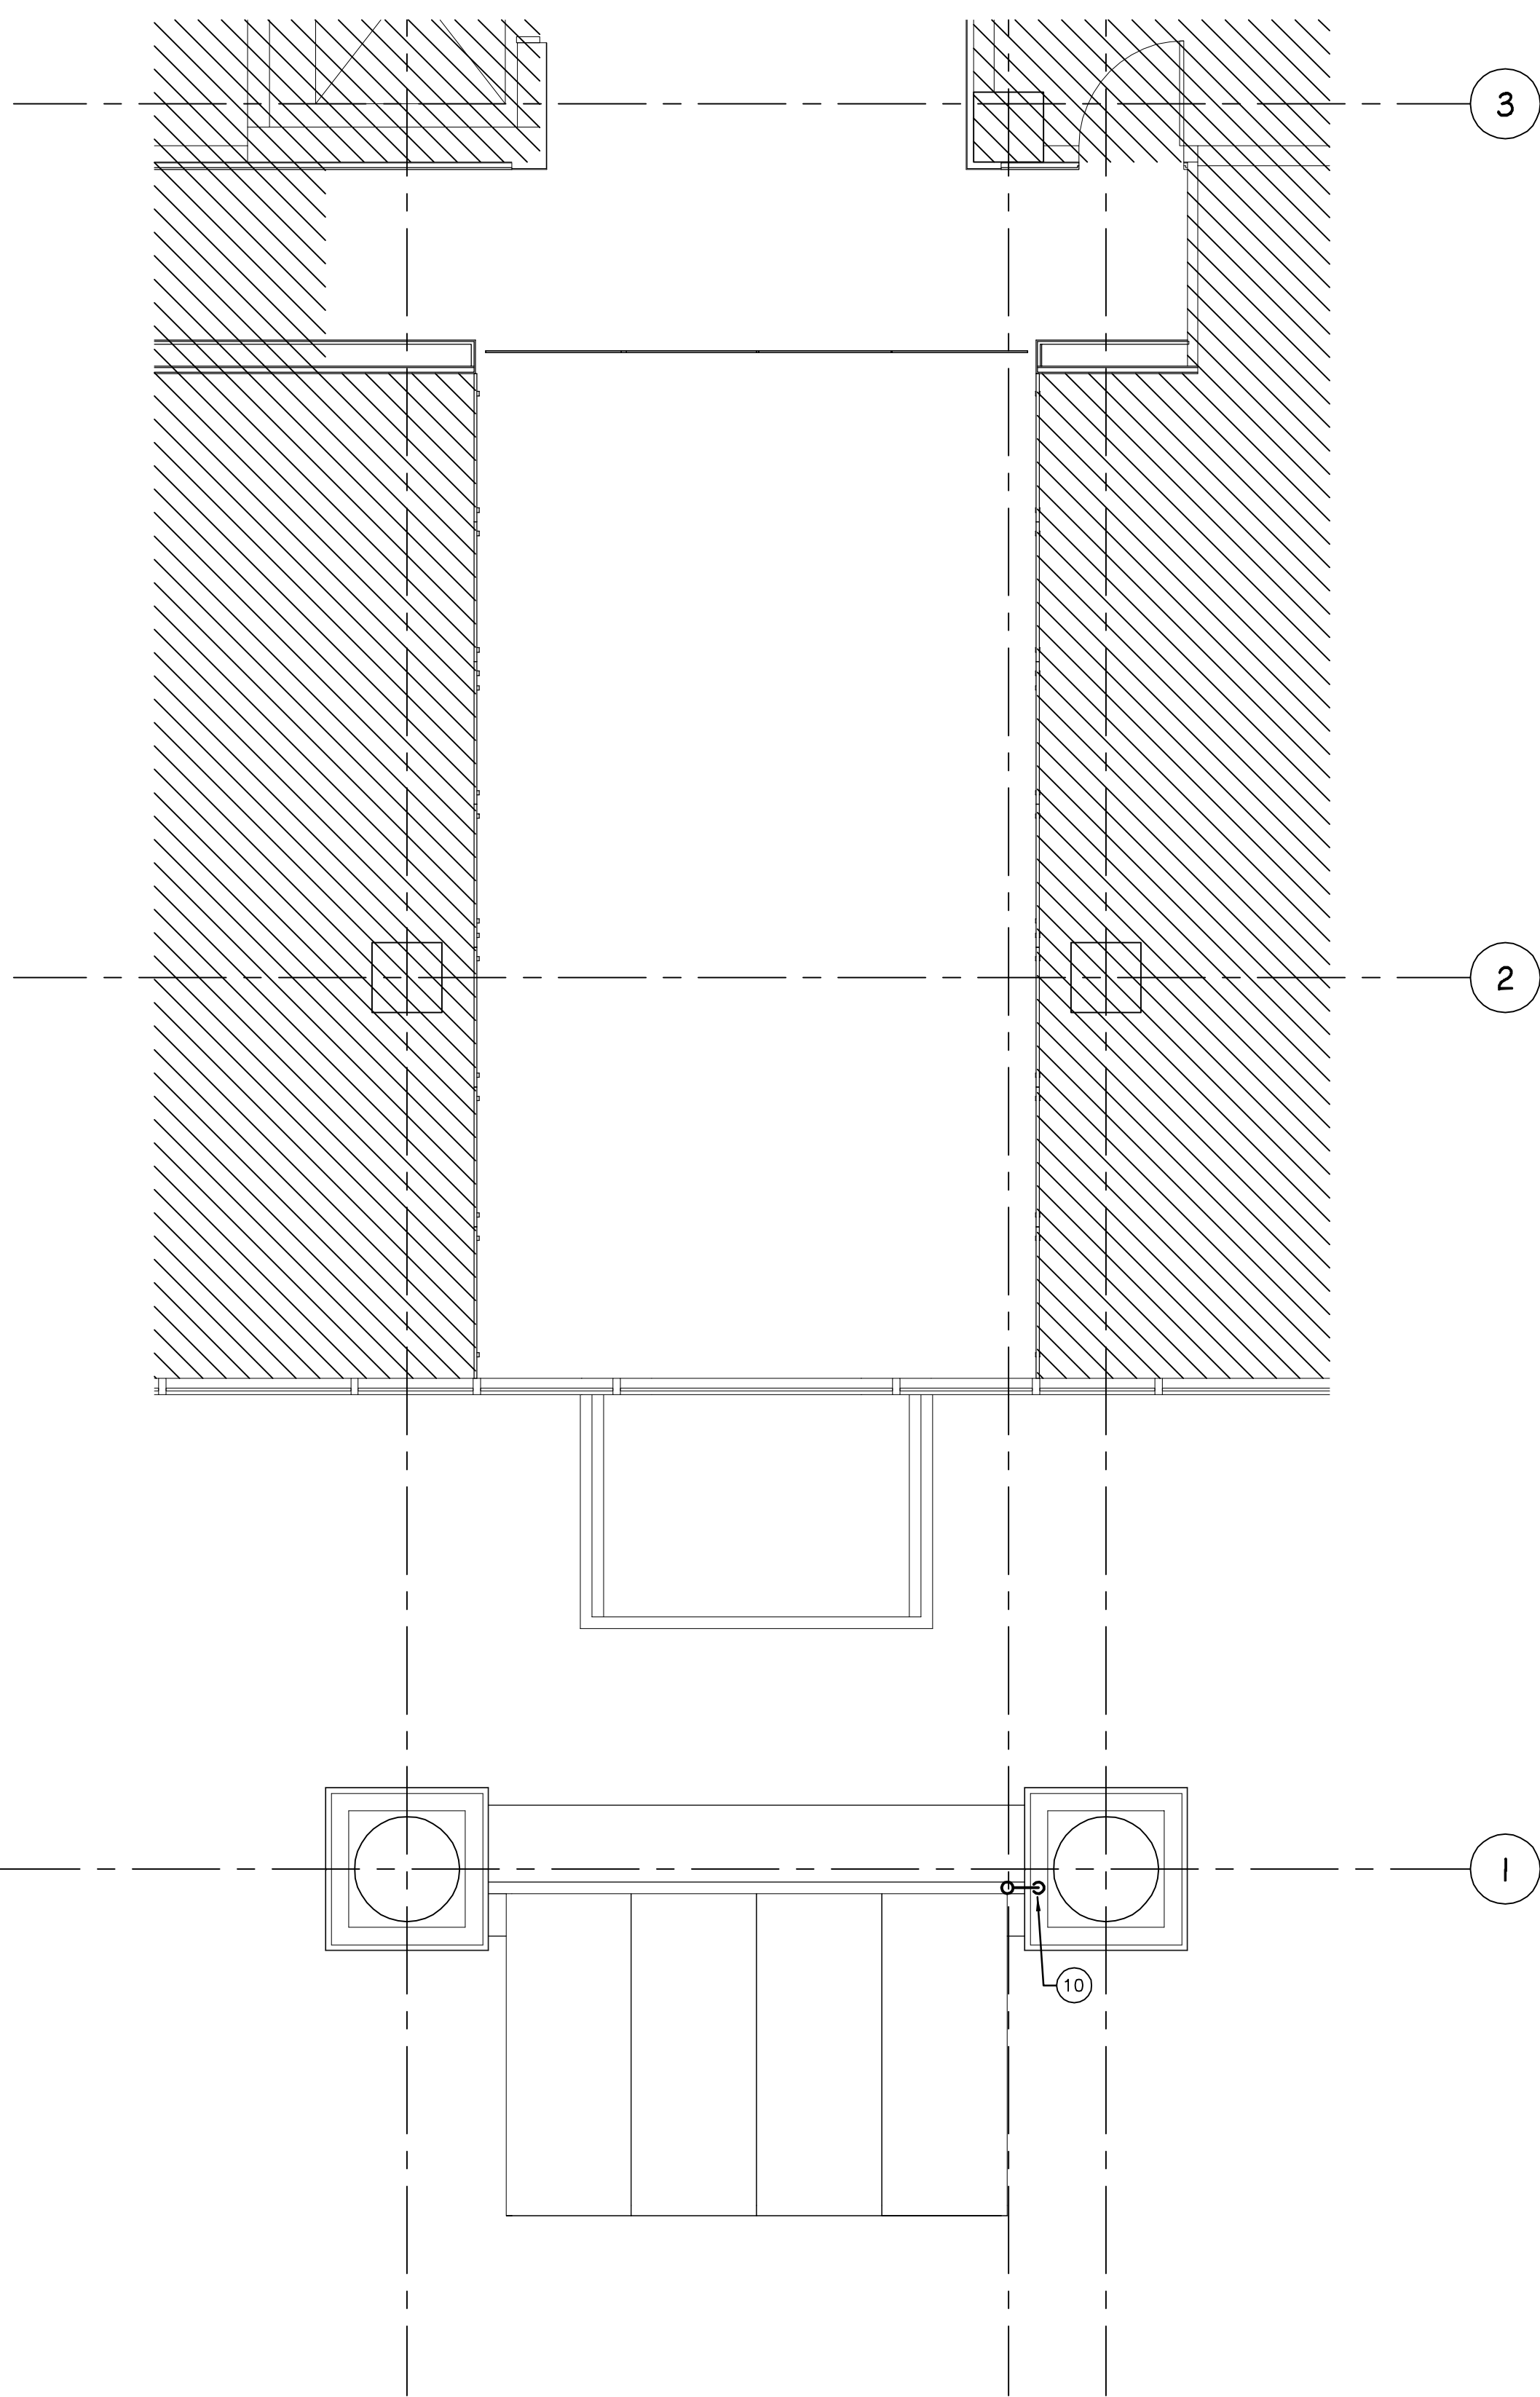

PARTIAL SECOND FLOOR PLAN – CONSTRUCTION ⑥⑦⑧⑨
SCALE: 1/4"=1'-0"

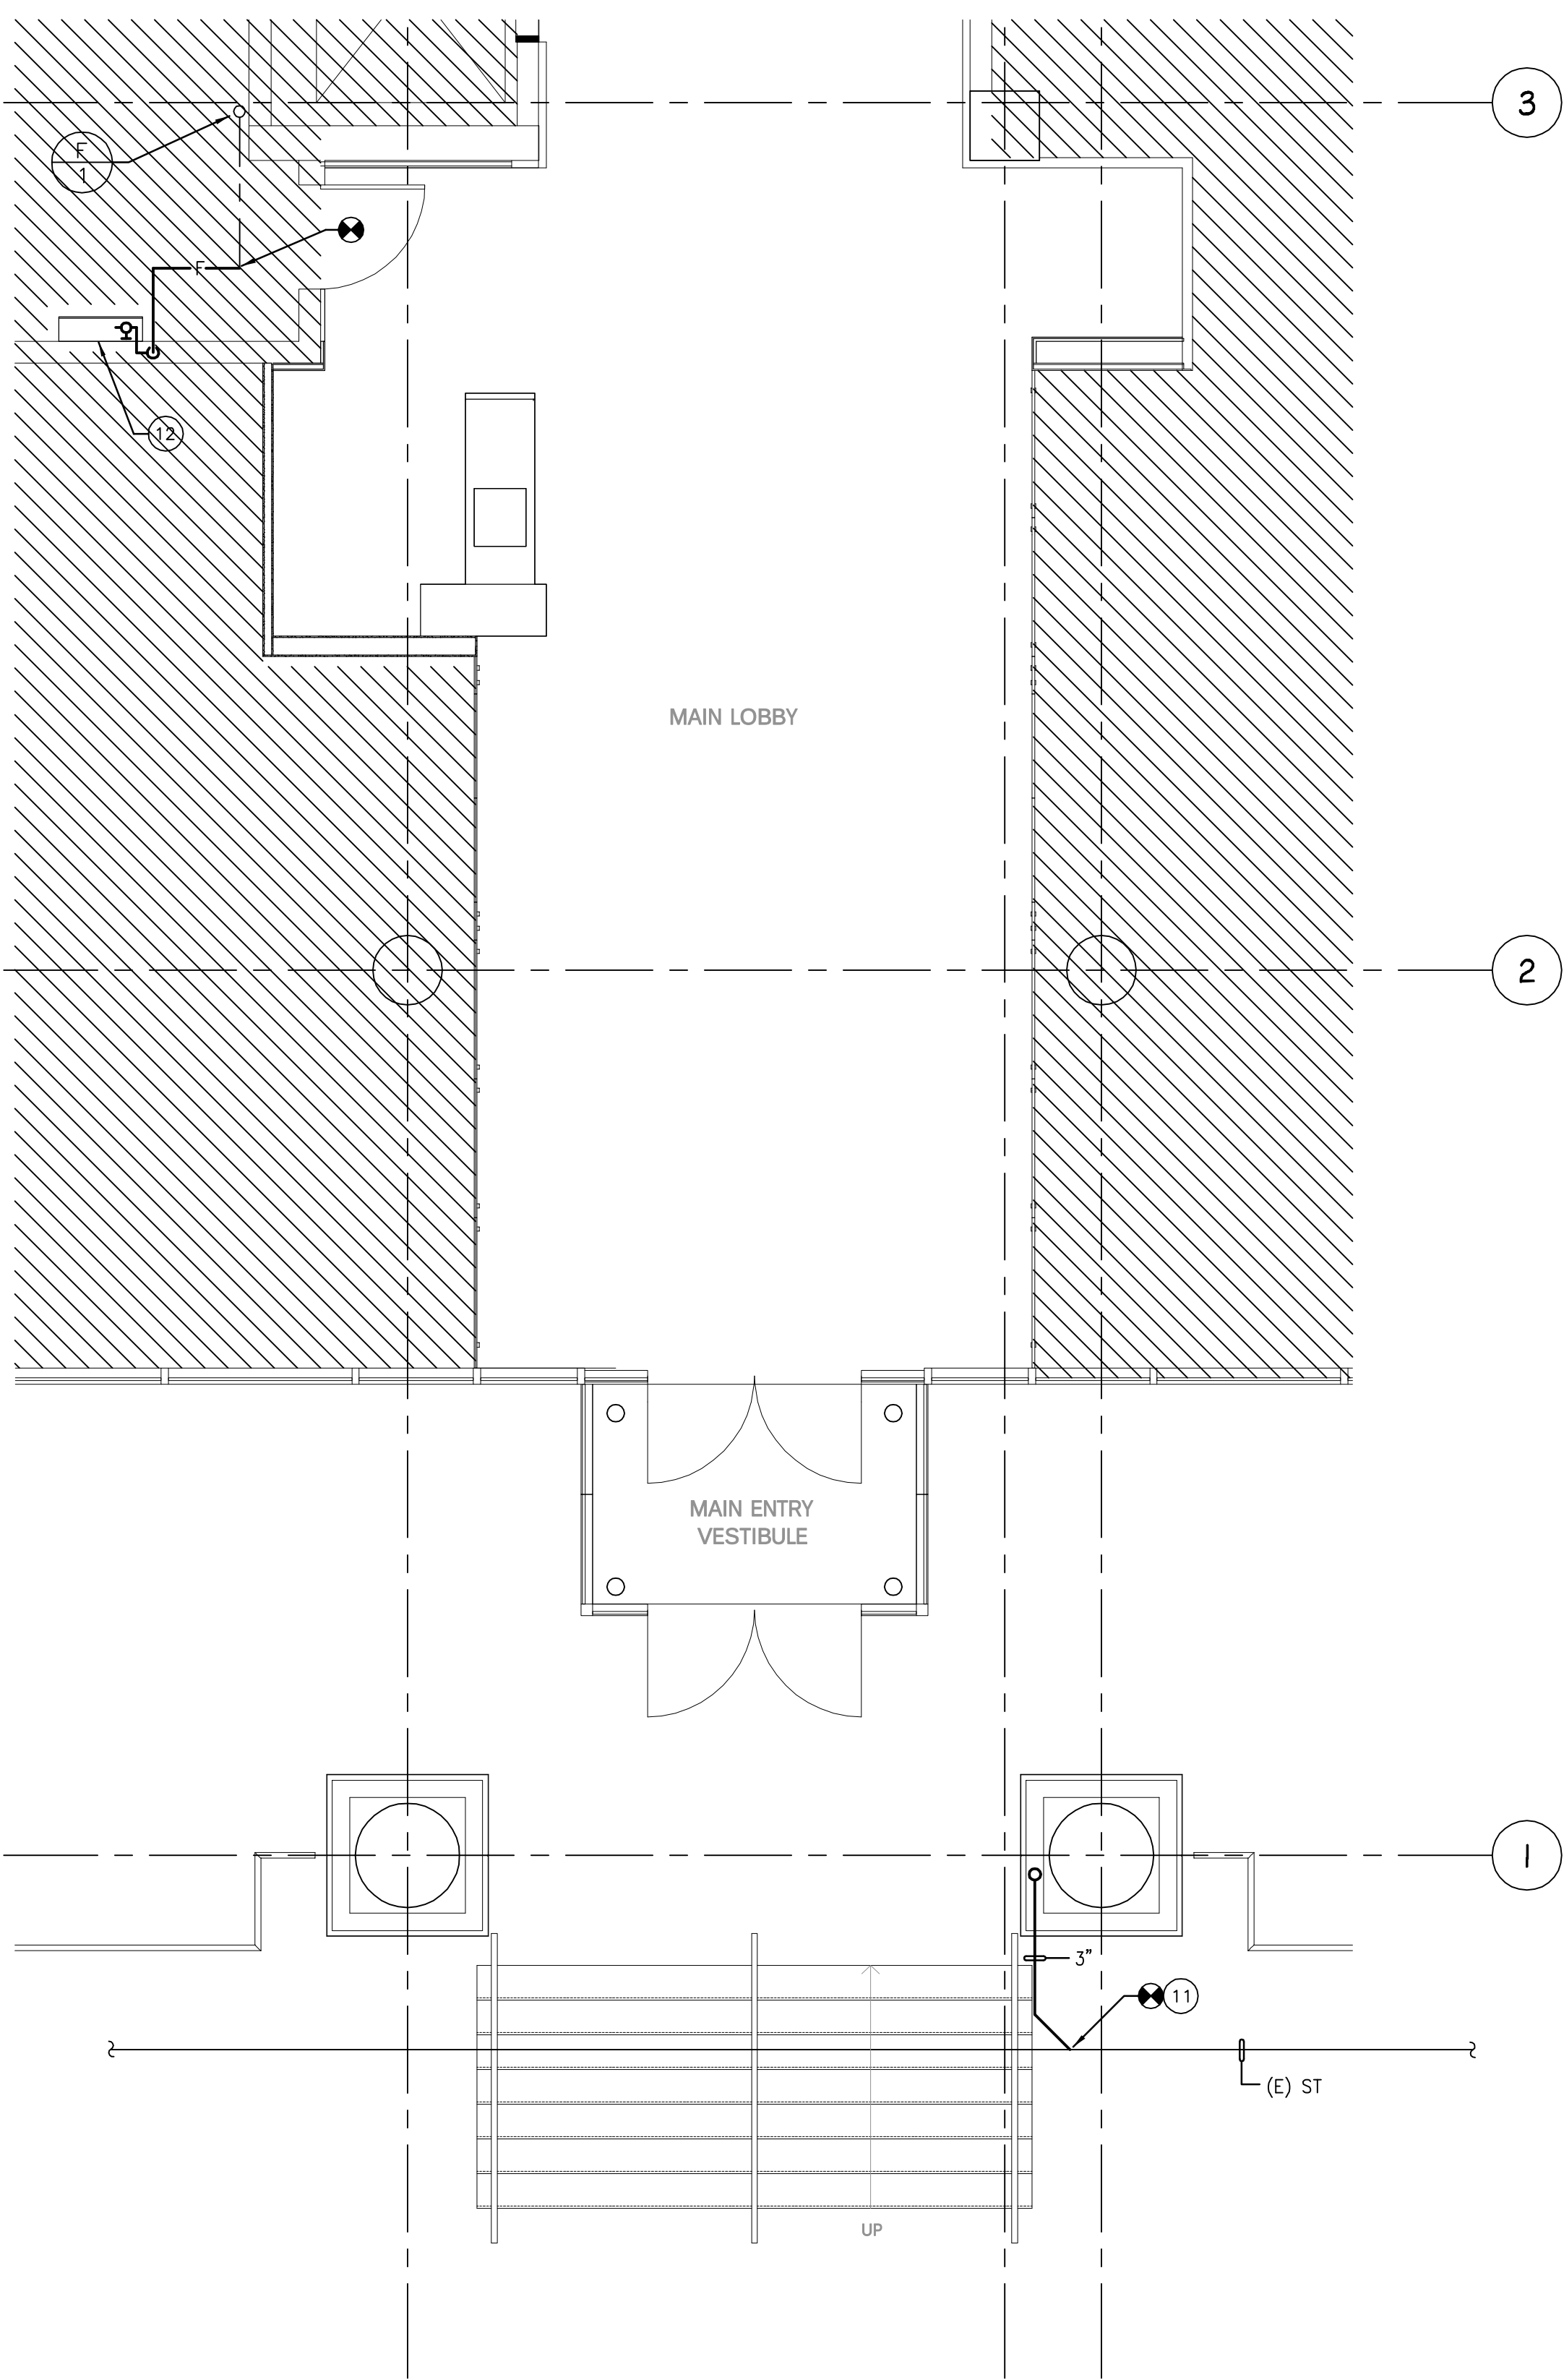

PARTIAL FIRST FLOOR PLAN – CONSTRUCTION ⑥⑦⑧⑨
SCALE: 1/4"=1'-0"

DRAWING NOTES – DEMOLITION

- ① EVERY EFFORT HAS BEEN MADE TO INDICATE ALL PIPING AND EQUIPMENT THAT IS BEING REMOVED THROUGH EXISTING DRAWINGS AND FIELD OBSERVATIONS. HOWEVER, THE CONTRACTOR IS TO VERIFY ALL REMOVALS, SOME DIFFERENCES MAY OCCUR.
- ② ALL PIPING IS SHOWN DIAGRAMMATICALLY. ALL WORK SHOWN BOLD AND/OR DASHED IS CONSIDERED TO BE DEMOLISHED UNDER THIS CONTRACT UNLESS NOTED OTHERWISE. CONTRACTOR TO VERIFY SIZES AND LOCATION OF EXISTING PIPING.
- ③ COORDINATE SCOPE OF WORK WITH ARCHITECTURAL DRAWINGS.
- ④ PATCH AND/OR REPAIR ALL SLAB OR RATED PARTITION OPENINGS IMMEDIATELY WHERE PIPES AND/OR PLUMBING FIXTURES HAVE BEEN REMOVED AS REQUIRED.
- ⑤ REMOVE EXISTING FIRE HOSE VALVE AND CABINET. CAP PIPING ABOVE CEILING.

DRAWING NOTES – CONSTRUCTION

- ⑥ ALL WORK SHOWN BOLD IS CONSIDERED AS NEW TO BE PROVIDED UNDER THIS CONTRACT UNLESS NOTED OTHERWISE.
- ⑦ CONTRACTOR SHALL VERIFY ALL PIPING SIZES AND LOCATIONS IN FIELD.
- ⑧ ALL PIPING IS SHOWN DIAGRAMMATICALLY.
- ⑨ ALL PIPING IS TO BE CONCEALED IN WALLS OR ABOVE CEILING.
- ⑩ NEW 3" STORM PIPING DOWN.
- ⑪ CONNECT NEW 3" STORM PIPING TO EXISTING PIPING BELOW SLAB.
- ⑫ NEW FIRE HOSE VALVE CABINET AND NEW FIRE HOSE VALVE.



WDG Architecture, PLLC
1025 Connecticut Avenue NW Suite 300
Washington DC 20036
tel 202 463 2198
fax 202 463 2198
e-mail wdg@wdgarch.com

Structural
Tadler-Cohen-Edelson
Associates
1109 Spring Street
Suite 510
Silver Spring, MD 20910
tel (301) 587-1820
fax (301) 588-1966
e-mail tadlerco.com

MEP
WFT Engineering, Inc.

9737 Washingtonian Boulevard
Suite 588
Gaithersburg, MD 20878
tel (301) 230-0811
fax (301) 330-8911
e-mail wfteng.com
wft job number 13074

7811 MONTROSE RD
POTOMAC, MD


**WILLCO
Companies**
7811 Montrose Road
Suite 500
Potomac, MD 20854

PERMIT SUBMISSION 10/15/13

Professional Seal
"PROFESSIONAL CERTIFICATION: I HEREBY CERTIFY THAT THESE DOCUMENTS WERE PREPARED OR APPROVED BY ME, AND THAT I AM A FULLY LICENSED PROFESSIONAL ENGINEER UNDER THE LAWS OF THE STATE OF MARYLAND, LICENSE NO. 15480, EXP. DATE 12/31/17"

© 2012 WDG Project No: WA111042

**FIRST & SECOND
FLOOR
DEMOLITION AND
NEW WORK PLAN:**
Scale: AS NOTED

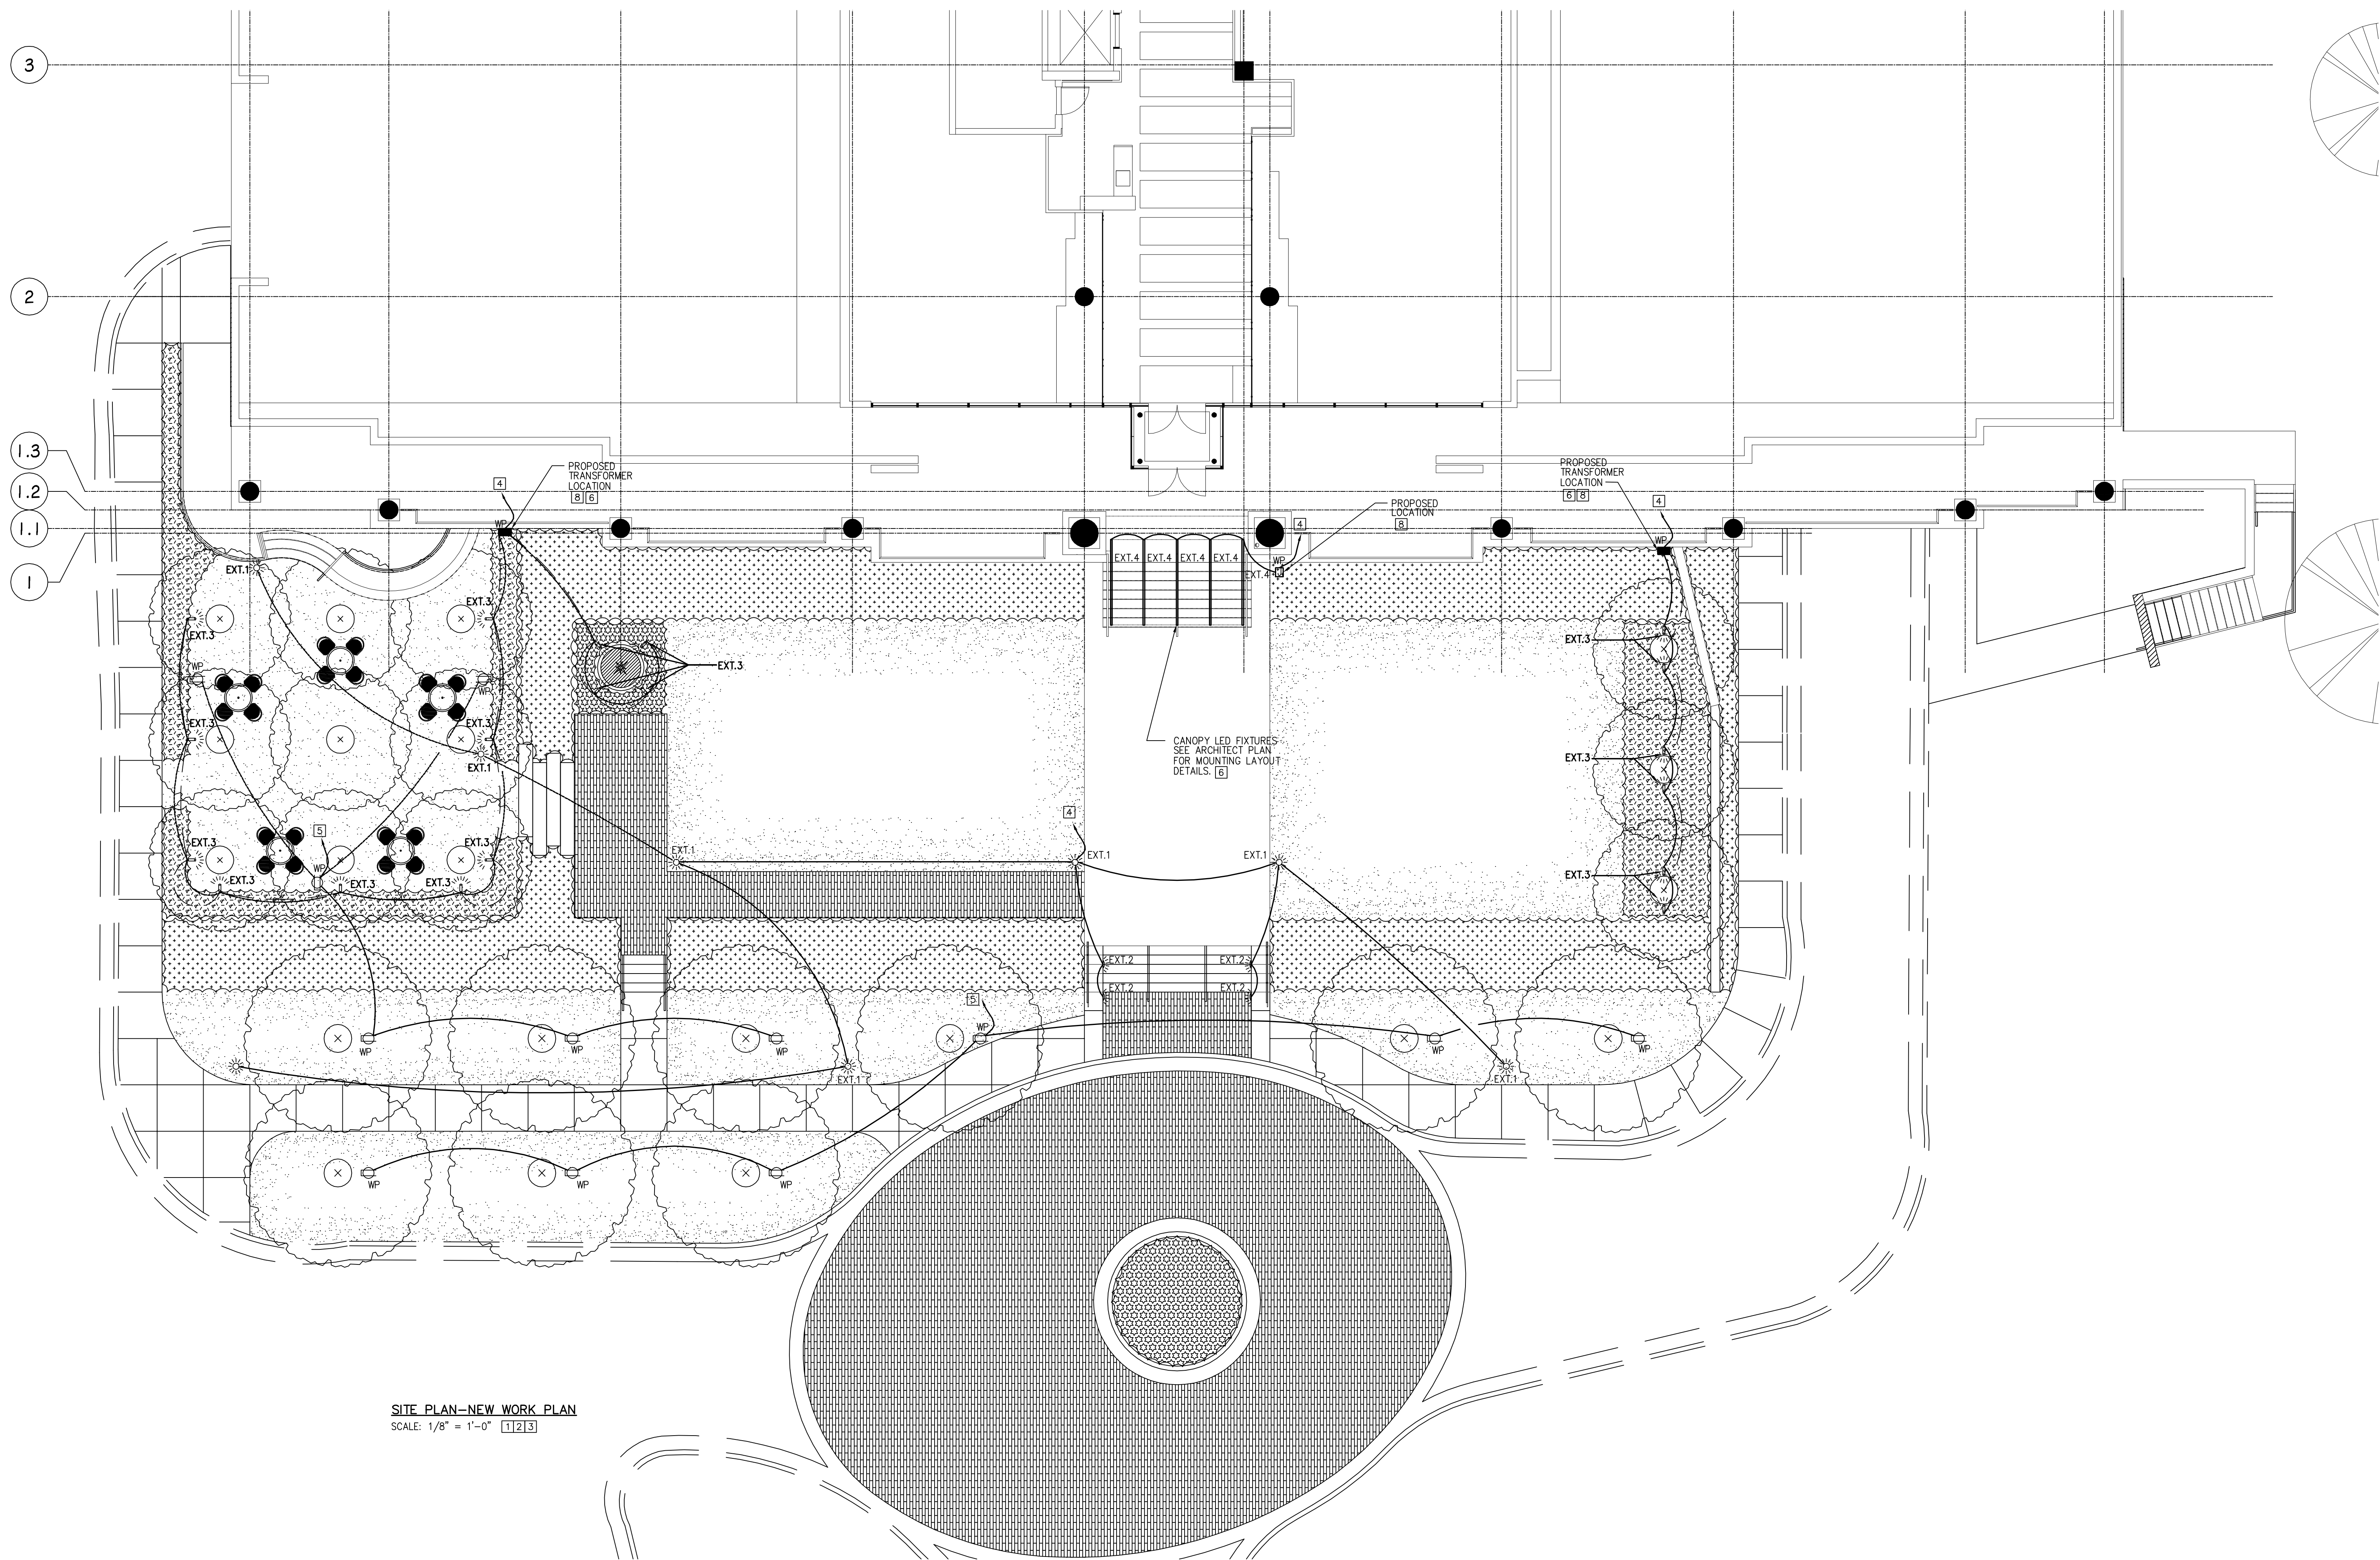

SITE PLAN-NEW WORK PLAN
SCALE: 1/8" = 1'-0" [1][2][3]

DRAWING NOTES -- DEMOLITION

1. ALL ELECTRICAL DEVICES/EQUIPMENT IN THIS AREA OF DEMOLITION WORK ARE TO BE REMOVED, UNLESS OTHERWISE INDICATED ON ARCHITECTURAL DRAWINGS.
2. REQUIRED DEMOLITION WORK SHALL NOT BE LIMITED TO THAT PORTION SHOWN ON PLANS ALONE, BUT SHALL INCLUDE ALL NECESSARY WORK TO BE NECESSARY BY THIS CONTRACTOR AFTER VISITING THE SITE PRIOR TO BIDDING. CONTRACTOR SHALL GATHER ALL THE INFORMATION AND COORDINATE WITH THE NEW OR MODIFIED WORK AS INDICATED ON THE DRAWINGS. ANY MAJOR DISCREPANCIES FOUND ON THE DRAWINGS AND SPECIFICATIONS SHALL BE BROUGHT TO THE ENGINEER'S ATTENTION, IN WRITING, BEFORE SUBMITTING THE BIDS.
3. THE SCHEDULING OF DEMOLITION WORK SHALL BE COORDINATED BY THIS CONTRACTOR WITH THE OWNER'S REPRESENTATIVE PRIOR TO PERFORMING THE WORK.
4. CONTRACTOR SHALL VISIT JOB SITE TO ASCERTAIN CONDITIONS WHICH MAY AFFECT HIS BID AND WORK, AND HE SHALL BE RESPONSIBLE FOR THE INCLUSION OF ALL REQUIRED DEMOLITION IN AREAS UNDERGOING MODIFICATION WHETHER OR NOT SUCH WORK IS INDICATED ON PLANS OR NOTES.
5. CONTRACTOR SHALL COORDINATE THE FOLLOWING WORK: EXISTING SWITCHES, TYPE OF SWITCHES AND SWITCHING SCHEME, THE FINAL WORK SHALL COMPLY WITH THE INTENT AS SHOWN ON THE DRAWINGS.
6. CONTRACTOR SHALL CLEAN THE PROJECT SITE AT THE END OF EACH WORKING DAY. AFTER REMOVAL OF ALL DEVICES, CONTRACTOR SHALL TURN ALL DEVICES OVER TO OWNER'S REPRESENTATIVE FOR HIM TO INSPECT. AFTER INSPECTION BY THE OWNER'S REPRESENTATIVE, CONTRACTOR SHALL REMOVE ALL UNWANTED DEVICES OR MATERIALS FROM THE SITE.
7. RETAIN EXISTING EXTERIOR CIRCUITRY MADE AVAILABLE DURING DEMOLITION IN THIS AREA FOR INTERCEPTION AND REUSE. CONTRACTOR SHALL VERIFY THE QUANTITY OF EXISTING CIRCUITS THAT ARE MADE AVAILABLE AFTER DEMOLITION WORK IS COMPLETED.

DRAWING NOTES -- NEW WORK PLAN

1. ALL LIGHTING FIXTURES ARE NEW UNLESS OTHERWISE NOTED.
2. REFER TO ARCHITECTURAL AND LANDSCAPE DRAWINGS / DETAILS FOR EXACT LOCATION, MOUNTING, QUALITIES AND LENGTHS OF ALL LIGHTING FIXTURES.
3. REFER TO ARCHITECTURAL DRAWINGS AND ELEVATIONS FOR ADDITIONAL REQUIREMENTS / INFORMATION. CONTRACTOR SHALL CONFIRM ELECTRICAL CHARACTERISTICS OF ALL EQUIPMENT WITH ARCHITECT AND OWNER. CONTRACTOR SHALL PROVIDE ALL CONDUIT, WIRING AND ACCESSORIES REQUIRED FOR A COMPLETE AND FULLY FUNCTIONAL SYSTEM.
4. RECONNECT TO EXISTING EXTERIOR LIGHTING CIRCUITRY THAT PREVIOUSLY SERVED THIS AREA. MODIFY EXISTING CIRCUITRY AS NECESSARY. RUN 2#12 IN 3/4" CONDUIT TO LIGHTS AS SHOWN. SEE NOTE 7 FOR MORE DETAILS.
5. RECONNECT TO EXISTING POWER CIRCUITRY THAT PREVIOUSLY SERVED THE EXTERIOR RECEPTACLES. MODIFY EXISTING CIRCUITRY AS NECESSARY. RUN 2#12 IN 3/4" CONDUIT TO RECEPTACLES AS SHOWN.
6. CONTRACTOR SHALL PROVIDE ALL CONDUIT, POWER SUPPLIES, WIRING AND ACCESSORIES REQUIRED BY FIXTURE MANUFACTURER FOR A COMPLETE AND FULLY FUNCTIONAL SYSTEM.
7. PROVIDED ADD/ALTERNATE PRICE FOR ADDING ADDITIONAL LIGHTING CONTRACTORS, CIRCUITS AND RELAYS IN EXISTING CONTROL PANEL OR PROVIDING AN NEW CONTROL PANEL SIMILAR TO THE GREENGATE LITEKEEPER 8, CAT# LK18-120NO WITH OVERRIDE SWITCH OR EQUAL. COORDINATE WITH ARCHITECT PRIOR TO BIDDING OF WORK.
8. PROVIDE A WEATHERPROOF JUNCTION BOX FOR FIXTURE ACCESSORIES IF NOT PROVIDED BY FIXTURE MANUFACTURER, FIELD COORDINATE.

WDG Architecture, PLLC
1025 Connecticut Avenue NW
Suite 300
Washington DC 20036
tel 202 857 8300
fax 202 463 2198
e-mail wdg@wdgarch.com

Structural
Tadler-Cohen-Edelson
Associates
1109 Spring Street
Suite 510
Silver Spring, MD 20910
tel (301) 587-1820
fax (301) 588-1966
e-mail tadlerco.com

MEP
WFT Engineering, Inc.

9737 Washingtonian Boulevard
Suite 588
Gaithersburg, MD 20878
tel (301) 230-0811
fax (301) 330-8911
e-mail wfteng.com
wft job number 13074

7811 MONTROSE RD
POTOMAC, MD

WILLCO
Companies
7811 Montrose Road
Suite 500
Potomac, MD 20854

PERMIT SUBMISSION 10/15/13

Professional Seal
"PROFESSIONAL CERTIFICATION: I HEREBY CERTIFY THAT THESE DOCUMENTS WERE PREPARED OR APPROVED BY ME, AND THAT I AM A FULLY LICENSED PROFESSIONAL ENGINEER UNDER THE LAWS OF THE STATE OF MARYLAND, LICENSE NO. 15480, EXP. DATE 12/31/17"

WDG Project No: WA11042
© 2012


ELECTRICAL
SITE PLAN

Scale: AS NOTED

(E) PNL. AAA			EXISTING PANELBOARD SCHEDULE													
			VOLTAGE	PHASE	WIRE	RATING	MAIN		AIC	NEUTRAL	GROUND BAR		MOUNTING	ENCLOSURE		
			208Y/120V	3	4	100 A	M L O		10 K	100%	YES		SURFACE	NEMA 1		
CIR.#	TYPE	DESCRIPTION	WIRE SIZE	COND. SIZE	BREAKER		LOAD (KVA)	PHASE	LOAD (KVA)	BREAKER		COND. SIZE	WIRE SIZE	DESCRIPTION	TYPE	CIR.#
					AMP	P				P	AMP					
1	O	(E) EQUIPMENT LOAD	E	E	20	2	1.60	A		3	100	E	E	MAIN BREAKER		2
3							1.60	B							4	
5							0.90	C							6	
7	R	(E) RECEPTACLES	E	E	20	1	1.50	A	1.08	1	20	E	E	(E) RECEPTACLES	R	8
9	O	(E) DUCT HEATER	E	E	20	3	1.50	B	1.08	1	20	E	E	(E) RECEPTACLES	R	10
11							1.50	C	0.90	1	20	E	E	(E) RECEPTACLES	R	12
13							1.08	A	1.90	3	20	E	E	(E) A/C UNIT	O	14
15	0.72	B	1.90	16												
17	1.08	C	1.90	18												
19		SPACE					A	0.36	1	20	3/4"	2#12 + 1#12G	***RECEPTS. LOBBY	R	20	
21		SPACE					B		1				SPACE		22	
23		SPACE					C		1				SPACE		24	

NOTES:										CONNECTED LOAD (KVA)			
*** PROVIDE AN NEW 1P,20A CIRCUIT BREAKER FOR NEW LOAD SHOWN. BREAKER TYPE TO MATCH EXISTING BREAKERS INSTALLED.										A	B	C	TOTAL
1). PROVIDE AND UPDATED PANEL DIRECTORY UPON COMPLETION OF WORK.													
2).										7.52	6.80	6.28	20.60
3).													

LOAD TYPE	LOAD (KVA)	[S] SUBLOADS (KVA)							CONNECTED LOAD (KVA)	DEMAND FACTORS		DEMAND LOAD (KVA)	RATING FACTOR	RATING LOAD (KVA)
		-	-	-	-	-	-	-						
[L] LIGHTING	0.00								0.00	100%		0.00	125%	0.00
[R] RECEPTACLES	7.20								7.20	1st 10KVA@100%+ REST@50%		7.20	100%	7.20
[M] MECHANICAL	0.00								0.00	100%		0.00	125%	0.00
[K] KITCHEN EQUIPMENT	0.00								0.00	#OF PIECES = 0	100%	0.00	100%	0.00
[O] OTHER	13.40								13.40	100%		13.40	100%	13.40
[E] EXISTING	0.00								0.00	100%		0.00	125%	0.00
TOTAL CONNECTED LOAD (KVA)=	20.60	0.00	0.00	0.00	0.00	0.00	0.00	0.00	20.60	TOTAL (KVA) =		20.60		20.60
										TOTAL AMPS =		57.18		57.18

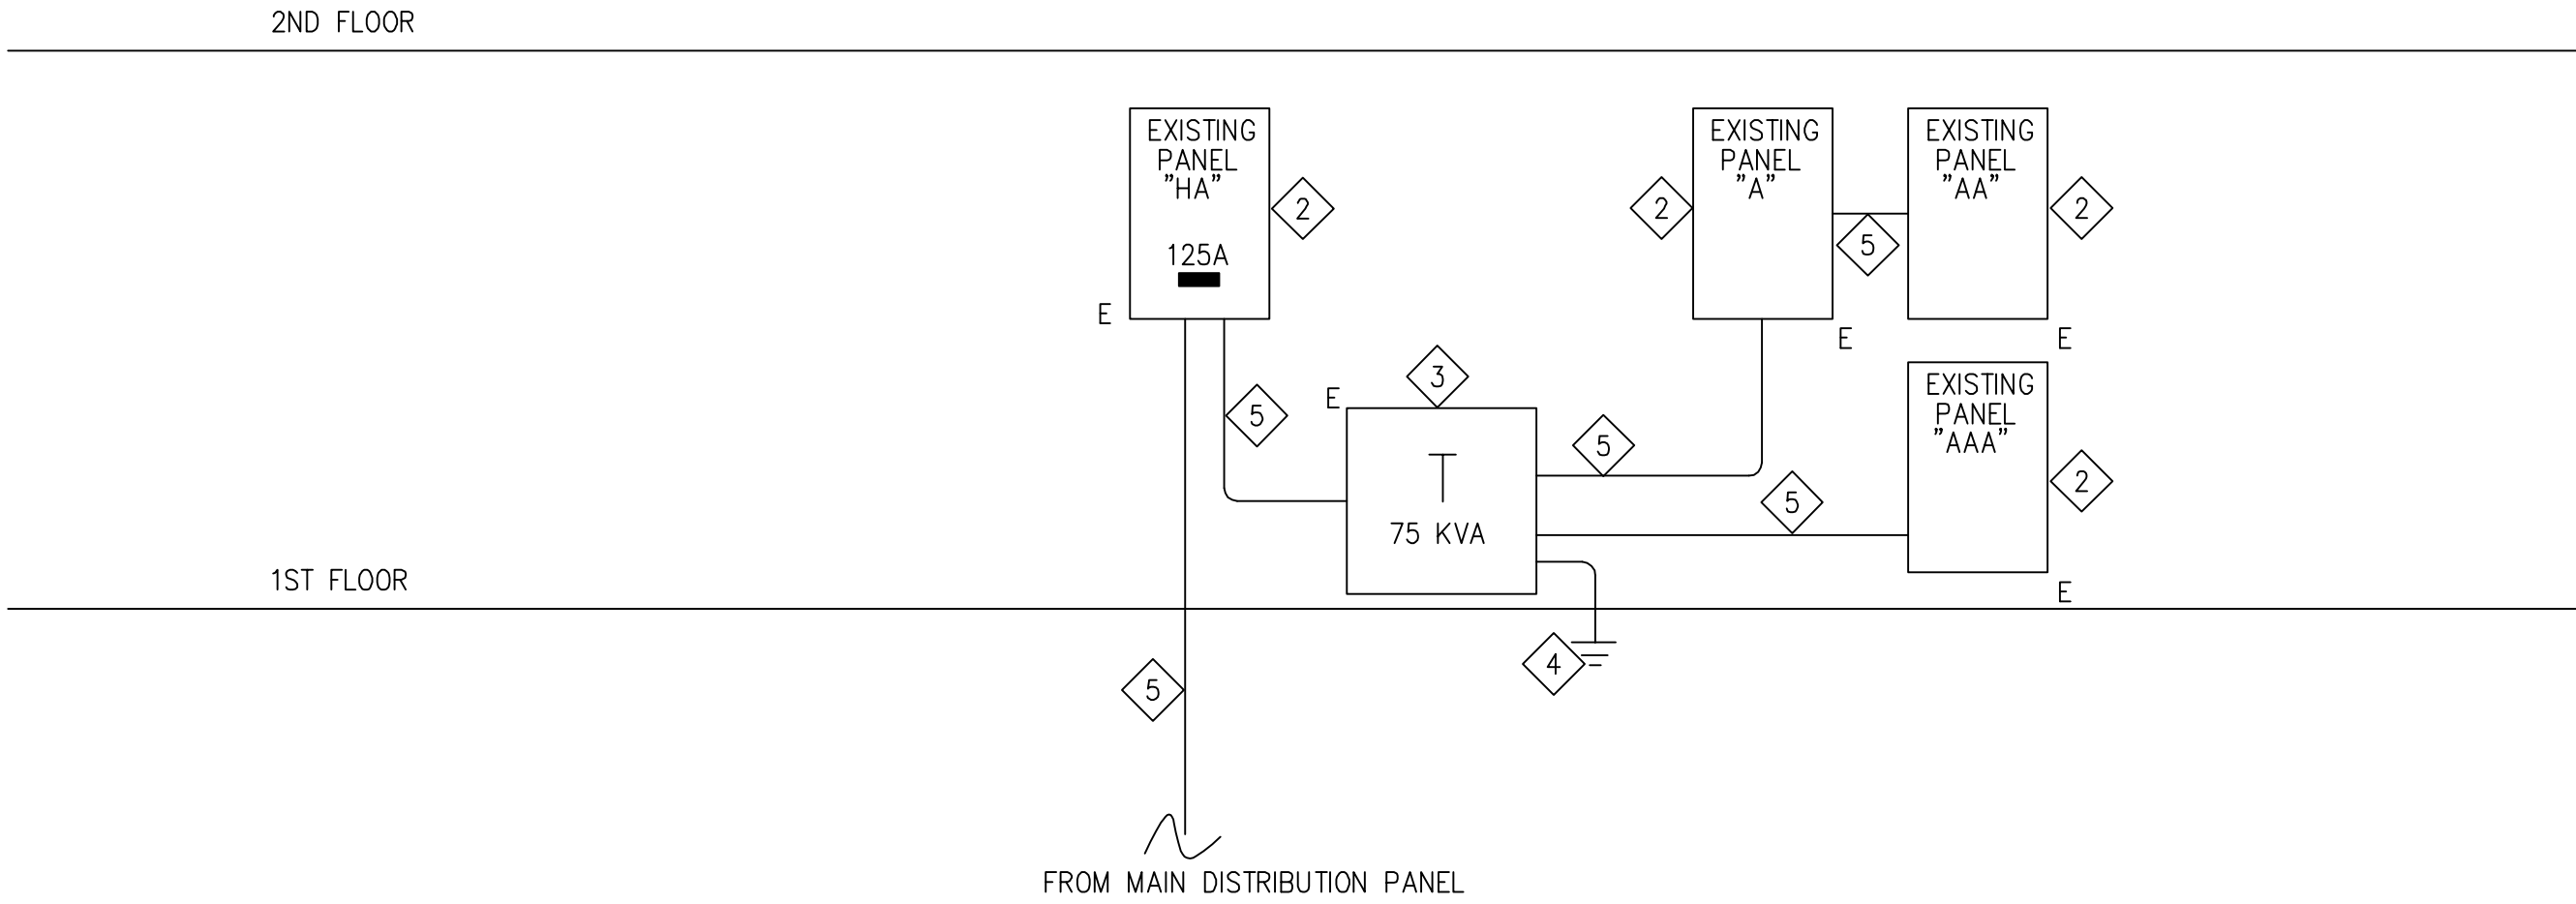

PARTIAL EXISTING RISER DIAGRAM
NO SCALE (FOR REFERENCE ONLY)

RISER NOTES:

- 1 ALL EQUIPMENT IS EXISTING TO REMAIN UNLESS OTHERWISE NOTED.
- 2 EXISTING PANEL TO REMAIN – SEE SCHEDULE FOR ADDITIONAL INFORMATION.
- 3 EXISTING 75KVA 480V, 3Ø TO 120/208V 3Ø, 4W, SECONDARY DRY TYPE TRANSFORMER.
- 4 EXISTING GROUND TO REMAIN
- 5 EXISTING FEEDER TO REMAIN.

PANEL SCHEDULE NOTES:

1. ALL NEW CIRCUIT BREAKER SHALL MATCH EXISTING CIRCUIT BREAKER TYPES INCLUDING INTERRUPTING CAPACITY.
2. PANELBOARD CIRCUIT LABELING: CIRCUITS SHALL BE LABELED TO INDICATE AREAS SERVED.

WDG Architecture, PLLC
1025 Connecticut Avenue NW
Suite 300
Washington DC 20036
tel 202 857 8300
fax 202 463 2198
e-mail wdg@wdgarch.com

Structural
Tadger-Cohen-Edelson
Associates
1109 Spring Street
Suite 510
Silver Spring, MD 20910
tel (301) 587-1820
fax (301) 588-1966
e-mail tadgerco.com

MEP
WFT Engineering, Inc.

9737 Washingtonian Boulevard
Suite 588
Gaithersburg, MD 20878
tel (301) 230-0811
fax (301) 330-8911
e-mail wfeing.com
wft job number 13074

7811 MONTROSE RD
POTOMAC, MD

WILLCO
Companies
7811 Montrose Road
Suite 500
Potomac, MD 20854

PERMIT SUBMISSION 10/15/13

Professional Seal

© 2012 WDG Project No: WA11042

ELECTRICAL
PANEL SCHEDULE
AND RISER
DIAGRAM

Scale: AS NOTED

E-6